



○ FRONT / WEST ELEVATION

Scale: 22x34 3/8" = 1'-0"
11x17 3/16" = 1'-0"

Design/Build

REDLEAF — HOMES —

17035 W. GREENFIELD AVENUE
NEW BERLIN, WI 53151
P: 414-248-5636
E: STEVE@REDLEAFWI.COM

Sheet Title

RENDERED FRONT ELEVATION

PERMIT PLANS

Revisions

No.	Date	Description
	08-08-2025	CONCEPT 1
	10-17-2025	CONCEPT 2
	12-09-2025	FOR STRUCTURAL ANALYSIS
	01-15-2026	PERMIT PLANS
	01-27-2026	RENDERING

VANDE BERG RESIDENCE
RE-BUILD

3902 N 102ND ST
WAUWATOSA, WI 53222

Sheet No.

A-5

VANDEBERG RESIDENCE EXTERIOR SELECTIONS

3920 N 102nd Street, Wauwatosa, WI 53222

ROOFING INFORMATION: See Exterior Elevations for all roof material locations.

- **Asphalt Shingles:** GAF Timberline Dimensional

Color: Weathered Wood



FASCIA & SOFFIT: LP SmartSide Pre-vented Soffit & Fascia

Color: Snowscape



GUTTER INFORMATION: Prefinished K-Style 5" Aluminum seamless

Color: ABC Rainware 80 White



DOWNSPOUT INFORMATION: 4" Aluminum Rectangular

Color: Match Gutters

SIDING INFORMATION: See Exterior Elevations for locations.

- **Lap Siding:** 8" SmartSide Lap Siding with 6" Exposed

Texture: Cedar

Color: Rapids Blue



- **Board & Batten Siding:** LP SmartSide Panel with 1x2 LP SmartSide Battens @ 16" O.C.

Texture: Cedar

Color: Rapids Blue

- **Corner Trim:** 3 1/2" LP SmartSide Trim

Texture: Cedar

Color: Rapids Blue

- **Door & Window Trim:** 3 1/2" LP SmartSide Trim

Texture: Cedar

Color: Snowscape

FRONT BEAM & BRACKET, WINDOW & GARAGE DOOR HEADERS:

Material: Douglas Fir

Texture: Rough

Stain: Custom Brown Ash, See sample



WINDOW INFORMATION: Marvin Essentials Double Hung Windows

Exterior/Interior: Ebony

Divided Lite Style: GBR - Grilles -Between-the-Glass



Ebony

FRONT DOOR INFORMATION: Simpson # 36812 SDL

Material: Doug Fir (Stain Grade)- **Glass:** Clear

Stain: Match Doug Fir Front Beam & Bracket (Custom Brown Ash)

Hardware Information: To be selected with all other hardware with Neu's Hardware



GARAGE DOOR INFORMATION: (1) 16X8' CHI Raised Panel Model #4283 OHD

Color: Black

Windows: Raised Panel Long

Window Inserts: Madison – Long

Glass: Plain/No Design

Exterior Hardware (Permanent): N/A



Black

VANDEBERG RESIDENCE PHOTO OF PHYSICAL EXTERIOR SAMPLES

3920 N 102nd Street, Wauwatosa, WI 53222



VANDE BERG EXTERIO LIGHT FIXTURE INFORMATION

LIGHT FIXTURE A & B



TROYER

1195BK

LARGE WALL MOUNT BARN LIGHT

Troyer's authentic outdoor collection captures the enduring allure of American farmhouse lighting. Constructed in solid aluminum, Troyer's warm and inviting heritage details combine with unique ribbed glass accent and timeless finishes for a classic silhouette.

DETAILS	
FINISH:	Black
MATERIAL:	Aluminum
GLASS:	Clear Ribbed
DIMMABLE:	YES - WITH DIMMABLE LAMP (NOT INCLUDED)

DIMENSIONS	
WIDTH:	14"
HEIGHT:	11.5"
WEIGHT:	2.5lb
BACK PLATE:	6" Dia.
EXTENSION:	24"
TOP TO OUTLET:	6.25"

LIGHT SOURCE	
LIGHT SOURCE:	Socketed
WATTAGE:	1-12w Med. LED, 100w Equiv.
VOLTAGE:	120v

SHIPPING	
CARTON LENGTH:	17
CARTON WIDTH:	11
CARTON HEIGHT:	22.5
CARTON WEIGHT:	4.5

PRODUCT DETAILS:

- Wet Rated
- Outdoor finishes carry a 2-year warranty
- Angular lines, a bold finish and robust details create an industrial edge to add flair to any type of facade
- Aluminum material ensures this piece can withstand strenuous outdoor conditions
- Mounted at a point of entry, wall mount lights provide safety and security with a welcoming element

LIGHT FIXTURE C: VAXCEL LIGHTING HIGHLAND PARK 10" TALL LED OUTDOOR WALL Sconce MODEL: T0804

Finish: Matte Black

Features: Constructed from steel
Comes with steel shade
Uses medium (E26) bulbs
ETL for wet locations
Title 24 compliant

Dimensions: Height: 9-1/2"
Extension: 11-1/4"
Shade Height: 3-7/8"
Shade Depth: 9"
Backplate Width: 4-3/4"

Width: 9"
Product Weight: 2.16 lbs
Shade Width: 9"
Backplate Height: 4-3/4"
Backplate Depth: 13/16"

Electrical Specifications:

Max Wattage: 60.0 watts
Watts Per Bulb: 60 watts
Bulb Type: LED

Number of Bulbs: 1
Bulb Base: Medium (E26)
Voltage: 120 volts



THREE LIGHTS IN ONE

- 1. MOTION SENSOR**
- 2. DUSK TO DAWN**
- 3. SWITCH CONTROLLED**

MULTI 3-IN-1 FUNCTION

VARIABLE LIGHT ACTIVATION VIA 3 UNIQUE MODES

FULLY CUSTOMIZABLE SETTINGS

CONVENIENT CONTROL ACCESS

MOTION SHUT-OFF DELAY
5 sec - 3 min

MOTION SENSITIVITY
30 ft

MODES of OPERATION
4 modes

30% LOW LEVEL STAND-BY

100% MOTION


HOW IT DUALUX WORKS

SECURITY OPTIONS TO FIT YOUR LIFESTYLE

Revisions

No.	Date	Description
	08-08-2025	CONCEPT 1
	10-17-2025	CONCEPT 2
	12-09-2025	FOR STRUCTURAL ANALYSIS
	01-15-2026	PERMIT PLANS
R-1	01-29-2026	PERMIT PLANS

**VANDE BERG
 RESIDENCE**
 RE-BUILD
 3920 N 102ND ST
 WAUWATOSA, WI 53222

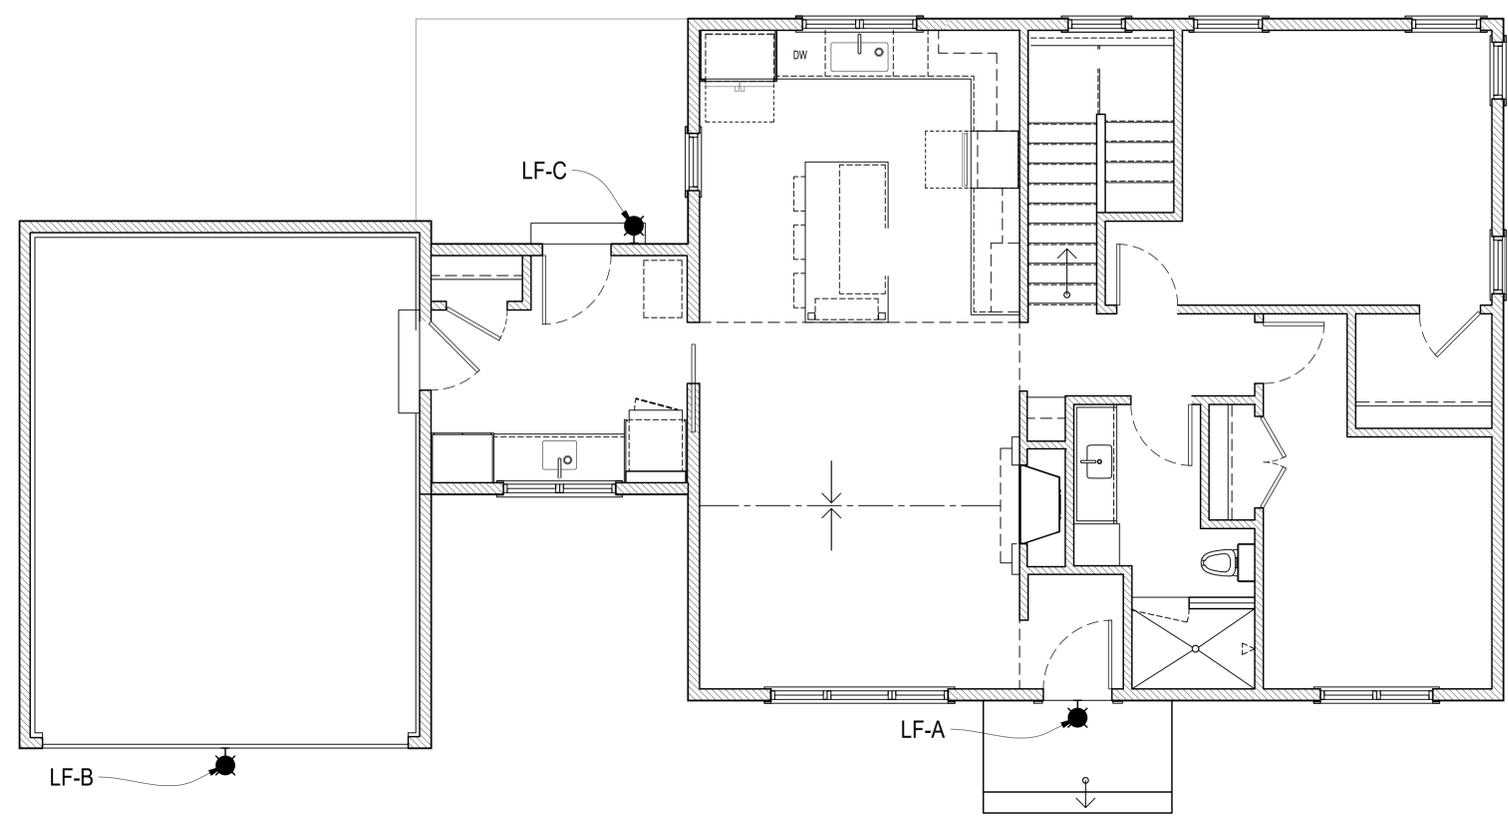

EXTERIOR LIGHTING PLAN
 Scale: 22x34 1/4" = 1'-0"
 11x17 1/8" = 1'-0"

LIGHT FIXTURE KEY																									
<p>LF-A & LF-B: FINISH: BLACK</p>	<table border="0"> <tr> <td>ITEM NUMBER</td> <td>1195DZ</td> </tr> <tr> <td>BRAND</td> <td>Hinkley Lighting</td> </tr> <tr> <td>MATERIAL</td> <td>Aluminum</td> </tr> <tr> <td>GLASS</td> <td>Ribbed Clear</td> </tr> <tr> <td>HEIGHT</td> <td>11.5"</td> </tr> <tr> <td>WIDTH</td> <td>14.0"</td> </tr> <tr> <td>VOLTAGE</td> <td>120v</td> </tr> <tr> <td>WATTAGE</td> <td>1-100w Med.</td> </tr> <tr> <td>CERTIFICATION</td> <td>C-US Wet Rated</td> </tr> <tr> <td>EXTENSION</td> <td>24.0"</td> </tr> <tr> <td>TOP TO OUTLET</td> <td>6.3"</td> </tr> <tr> <td>BACK PLATE</td> <td>6" Dia.</td> </tr> </table> <p>FEATURES AND BENEFITS</p> <ul style="list-style-type: none"> • Suitable for use in wet (interior direct splash and outdoor direct rain or sprinkler) locations as defined by NEC and CEC. Meets United States UL Underwriters Laboratories & CSA Canadian Standards Association Product Safety Standards • For complete warranty information visit (hyperlink) • 2 year finish warranty • 12 year warranty on electrical wiring and components • Angular lines, a bold finish and robust details create an industrial edge to add flair to any type of façade • Rich gray tone 	ITEM NUMBER	1195DZ	BRAND	Hinkley Lighting	MATERIAL	Aluminum	GLASS	Ribbed Clear	HEIGHT	11.5"	WIDTH	14.0"	VOLTAGE	120v	WATTAGE	1-100w Med.	CERTIFICATION	C-US Wet Rated	EXTENSION	24.0"	TOP TO OUTLET	6.3"	BACK PLATE	6" Dia.
ITEM NUMBER	1195DZ																								
BRAND	Hinkley Lighting																								
MATERIAL	Aluminum																								
GLASS	Ribbed Clear																								
HEIGHT	11.5"																								
WIDTH	14.0"																								
VOLTAGE	120v																								
WATTAGE	1-100w Med.																								
CERTIFICATION	C-US Wet Rated																								
EXTENSION	24.0"																								
TOP TO OUTLET	6.3"																								
BACK PLATE	6" Dia.																								
<p>LF-C:</p>	<p>VAXCEL LIGHTING HIGHLAND PARK 10" TALL LED OUTDOOR WALL Sconce MODEL: T0804 Finish: Matte Black</p> <table border="0"> <tr> <td>Features:</td> <td>Constructed from steel Comes with steel shade Uses medium (E26) bulbs ETL for wet locations Title 24 compliant</td> </tr> <tr> <td>Dimensions:</td> <td>Height: 9-1/2" Extension: 11-1/4" Shade Height: 3-7/8" Shade Depth: 9" Backplate Width: 4-3/4"</td> </tr> <tr> <td>Electrical Specifications:</td> <td>Max. Wattage: 60.0 watts Watts Per Bulb: 60 watts Bulb Type: LED</td> </tr> </table> <p>Width: 9" Product Weight: 2.16 lbs Shade Width: 9" Backplate Height: 4-3/4" Backplate Depth: 13/16"</p> <p>Number of Bulbs: 1 Bulb Base: Medium (E26) Voltage: 120 volts</p>	Features:	Constructed from steel Comes with steel shade Uses medium (E26) bulbs ETL for wet locations Title 24 compliant	Dimensions:	Height: 9-1/2" Extension: 11-1/4" Shade Height: 3-7/8" Shade Depth: 9" Backplate Width: 4-3/4"	Electrical Specifications:	Max. Wattage: 60.0 watts Watts Per Bulb: 60 watts Bulb Type: LED																		
Features:	Constructed from steel Comes with steel shade Uses medium (E26) bulbs ETL for wet locations Title 24 compliant																								
Dimensions:	Height: 9-1/2" Extension: 11-1/4" Shade Height: 3-7/8" Shade Depth: 9" Backplate Width: 4-3/4"																								
Electrical Specifications:	Max. Wattage: 60.0 watts Watts Per Bulb: 60 watts Bulb Type: LED																								

DRAWING ONLY


LOCATION: 3920 North 102nd Street, Wauwatosa, Wisconsin

LEGAL DESCRIPTION:

That part of the Northwest 1/4 of Section 8, Town 7 North, Range 21 East, in the City of Wauwatosa, Milwaukee County, Wisconsin, bounded and described as follows: Commencing at the Northeast corners of said 1/4 Section, thence South 89°41'00" West along the North line of said 1/4 Section, 698.07 feet to a point; thence South 00°01'00" East 459.28 feet to the Northwest corner of land to be described; thence North 89°59'00" East 99.59 to a point; thence South 62°00'00" East, 2.44 feet; thence South 87°56'15" East, 108.39 feet; thence due South, 98.52 feet; thence South 89°59'00" West, 210.04 feet; thence North 00°01'00" West, 103.60 feet to the point of beginning. Excepting therefrom the West 30.00 feet for road right-of-way. Continuing 18,310.4 square feet (.42 acres) of land.

August 26, 2025 (Drawing Only)

Survey No. 116223

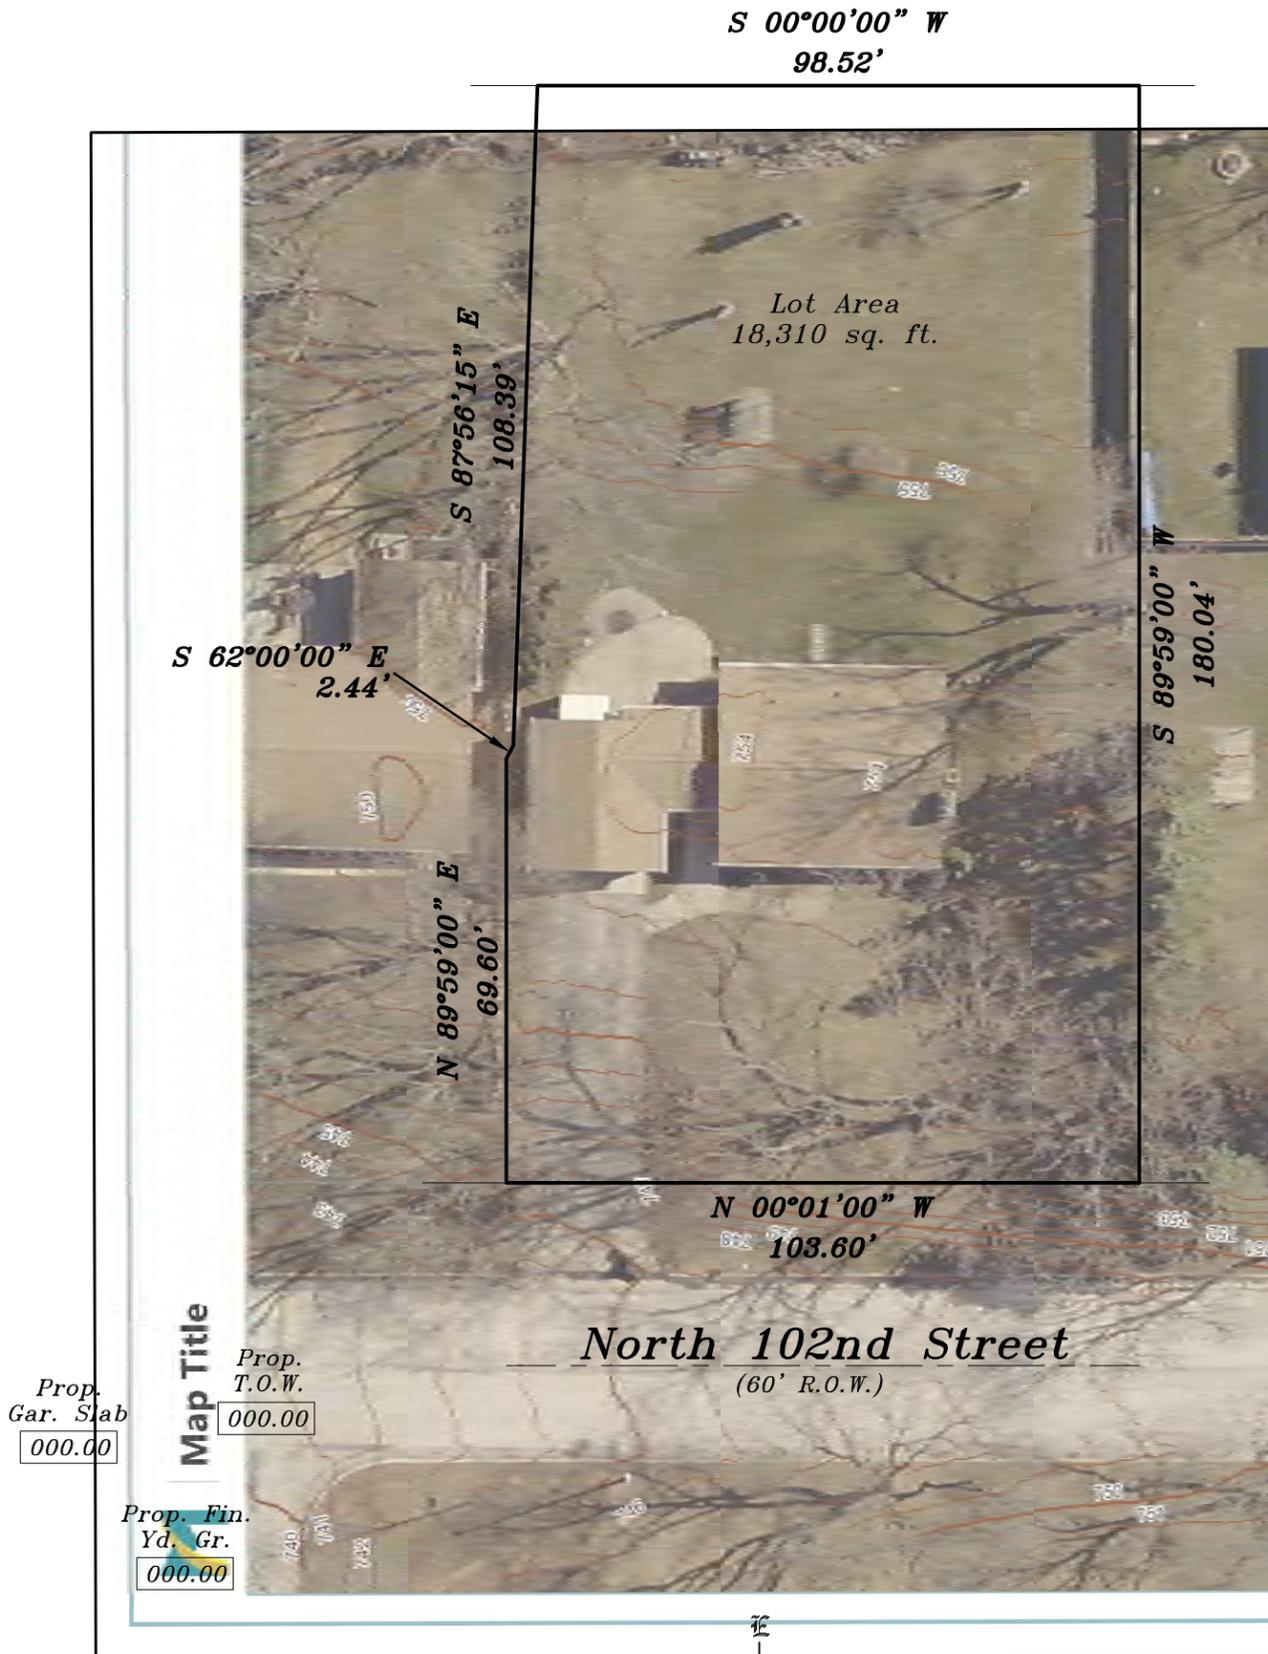

Proposed finished yard, 1st floor or top of foundation grade shown on this drawing is a suggested grade and should be verified by the owner, builder or municipality.

METROPOLITAN SURVEY SERVICE, INC.

PROFESSIONAL LAND SURVEYORS

8482 South 76th Street

Franklin, Wisconsin 53132

PHONE (414) 529-5380

survey@metropolitansurvey.com

www.metropolitansurvey.com




⊙ — Denotes Iron Pipe Found


○ — Denotes Iron Pipe Set

000.0 — Denotes Proposed Grade

—x—x—x— Denotes Proposed Silt Screen

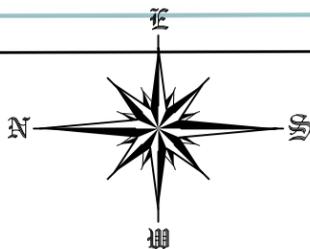

GRAPHIC SCALE

 

(IN FEET)

1 inch = 30 ft.

I HEREBY CERTIFY THAT I HAVE SURVEYED THE ABOVE DESCRIBED PROPERTY AND THAT THE ABOVE MAP IS A TRUE REPRESENTATION THEREOF AND SHOWS THE SIZE AND LOCATION OF THE PROPERTY. ITS EXTERIOR BOUNDARIES, THE LOCATION OF ALL VISIBLE STRUCTURES AND DIMENSIONS OF ALL PRINCIPAL BUILDINGS THEREON, BOUNDARY FENCES, APPARENT EASEMENTS AND ROADWAYS AND VISIBLE ENCROACHMENT, IF ANY.

THIS SURVEY IS MADE FOR THE EXCLUSIVE USE OF THE PRESENT OWNERS OF THE PROPERTY, AND ALSO THOSE WHO PURCHASE, MORTGAGE, OR GUARANTEE THE TITLE THERETO WITHIN ONE (1) YEAR FROM THE DATE HEREOF.

SIGNED _____

Dennis C. Sauer

Professional Land Surveyor S-2421

PLAT OF SURVEY

LOCATION: 3920 North 102nd Street, Wauwatosa, Wisconsin

LEGAL DESCRIPTION:


That part of the Northwest 1/4 of Section 8, Town 7 North, Range 21 East, in the City of Wauwatosa, Milwaukee County, Wisconsin, bounded and described as follows: Commencing at the Northeast corners of said 1/4 Section, thence South 89°41'00" West along the North line of said 1/4 Section, 698.07 feet to a point; thence South 00°01'00" East 459.28 feet to the Northwest corner of land to be described; thence North 89°59'00" East 99.59 to a point; thence South 62°00'00" East, 2.44 feet; thence South 87°56'15" East, 108.39 feet; thence due South, 98.52 feet; thence South 89°59'00" West, 210.04 feet; thence North 00°01'00" West, 103.60 feet to the point of beginning. Excepting therefrom the West 30.00 feet for road right-of-way. Continuing 18,310.4 square feet (.42 acres) of land.

September 15, 2025

Survey No. 116223

January 16, 2026 Added Foundation Plan (Not Staked)


January 21, 2026 Added Proposed Grading (Not Staked)

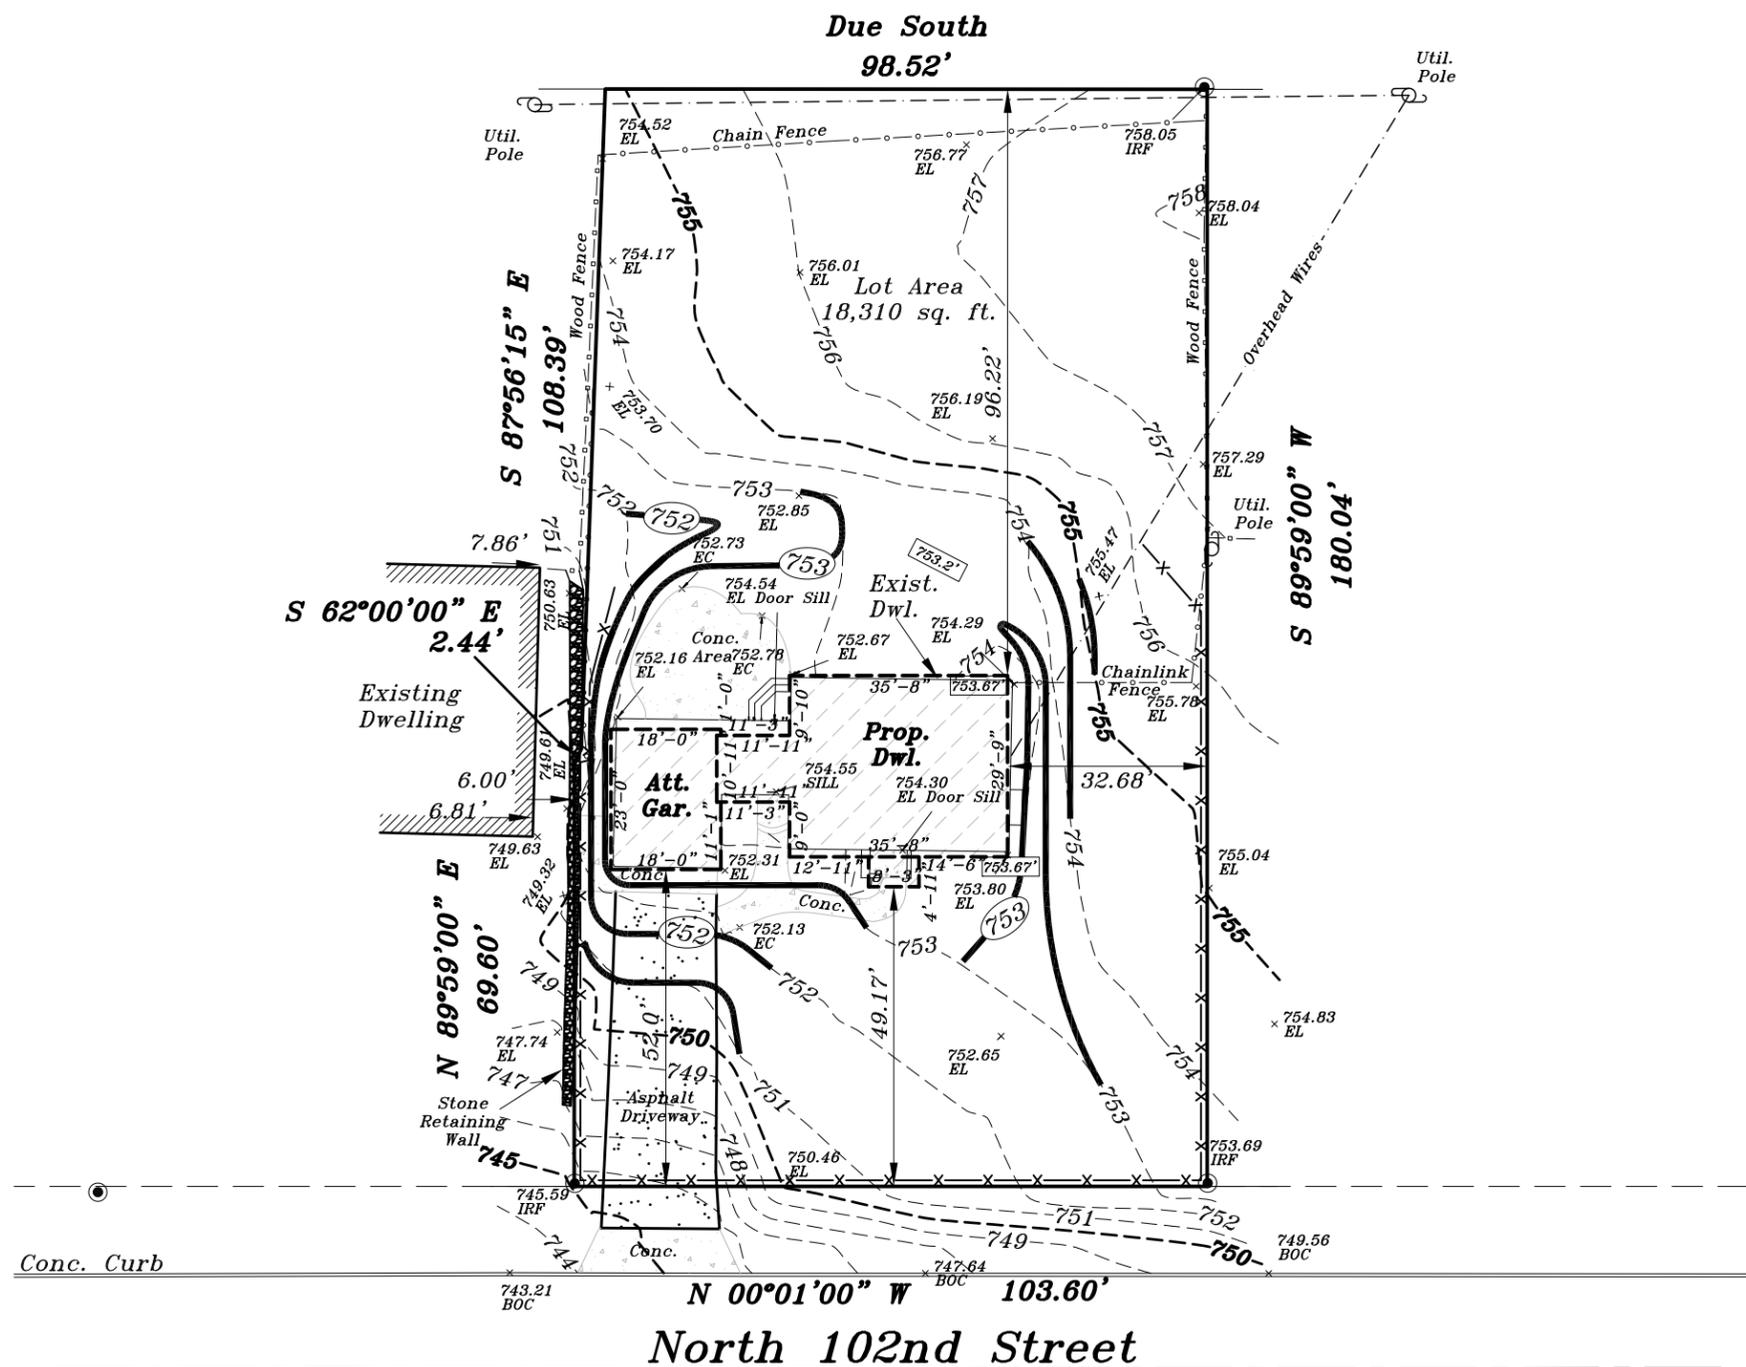

Prop. Gar. Slab
753.33'
(8" drop)

Prop. T.O.W.
754.33'

Prop. Fin. Yd. Gr.
753.67'

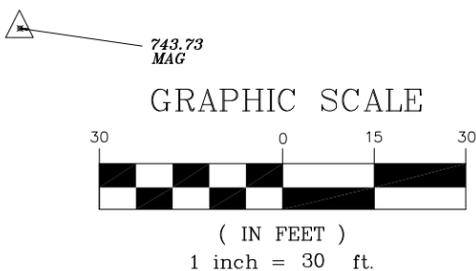

Proposed finished yard, 1st floor or top of foundation grade shown on this drawing is a suggested grade and should be verified by the owner, builder or municipality.

---○--- Denotes Existing Contour
---●--- Denotes Proposed Contour

METROPOLITAN SURVEY SERVICE, INC.

PROFESSIONAL LAND SURVEYORS

8482 South 76th Street
Franklin, Wisconsin 53132
PHONE (414) 529-5380

survey@metropolitansurvey.com
www.metropolitansurvey.com

● — Denotes Iron Rod Found
○ — Denotes Iron Pipe Set

000.0 — Denotes Proposed Grade
---x--- Denotes Proposed Silt Screen

I HEREBY CERTIFY THAT I HAVE SURVEYED THE ABOVE DESCRIBED PROPERTY AND THAT THE ABOVE MAP IS A TRUE REPRESENTATION THEREOF AND SHOWS THE SIZE AND LOCATION OF THE PROPERTY. ITS EXTERIOR BOUNDARIES, THE LOCATION OF ALL VISIBLE STRUCTURES AND DIMENSIONS OF ALL PRINCIPAL BUILDINGS THEREON, BOUNDARY FENCES, APPARENT EASEMENTS AND ROADWAYS AND VISIBLE ENCROACHMENT, IF ANY.

THIS SURVEY IS MADE FOR THE EXCLUSIVE USE OF THE PRESENT OWNERS OF THE PROPERTY, AND ALSO THOSE WHO PURCHASE, MORTGAGE, OR GUARANTEE THE TITLE THERETO WITHIN ONE (1) YEAR FROM THE DATE HEREOF.



SIGNED

Dennis C. Sauer

Dennis C. Sauer
Professional Land Surveyor S-2421

STRUCTURAL KEY:

FOOTINGS:

F-01: 42"x 42" x 12" W/ (3) #5 E. W.

FLOOR FRAMING:

FJ-01: (2) 11-7/8" LVL

BEAMS:

FB-01: W8 x 18
 FB-02: (2) 11-7/8" LVL
 FB-03: (2) 11-7/8" LVL

HEADERS-WINDOW & DOOR:

H-01: SEE SHEET S-0

STEEL COLUMNS:

C-01: 3" DIAMETER STANDARD PIPE COLUMN

ROOF FRAMING:

PRE-ENGINEERED TRUSSED DESIGNED BY TRUSS COMPANY

WALL BRACING:

WSP: WOOD STRUCTURAL PANEL SHEATHING, MIN. 48" LONG, MIN. 7/16" OSB OR PLYWOOD SHEATHING FASTENED WITH 8d NAILS @ 6" O.C. ALONG ALL PANEL EDGES AND 12" O.C. IN THE FIELD. PROVIDE BLOCKING AT ALL PANEL JOINTS.

PF: PORTAL FRAME (NARROW WALL BRACING) PER WISCONSIN UNIFORM DWELLING CODE (UDC) FIGURE 321.25-A.


CS-WSP: CONTINUOUSLY SHEATHED SHEARWALL WITH WOOD STRUCTURAL PANEL SHEATHING ON ENTIRE LENGTH OF WALL, FULL HEIGHT DIMENSIONS AS SHOWN ON PLAN. MIN 7/16" OSB OR PLYWOOD SHEATHING FASTENED WITH 8d NAILS @ 6" O.C. ALONG ALL PANEL EDGES & 12" O.C. IN THE FIELD. PROVIDE BLOCKING AT ALL PANEL JOINTS.

BUILDING INFORMATION:

BASEMENT		1,191 SQ FT
-FINISHED	571 SQ FT	
-UNFINISHED	620 SQ FT	
FIRST FLOOR*		1,191 SQ FT
-FRONT PORCH**	41 SQ FT	
-PATIO	110 SQ FT	
GARAGE		405 SQ FT

NOTES:

- * INCLUDES STAIRS TO BASEMENT
- ** INCLUDES STAIR

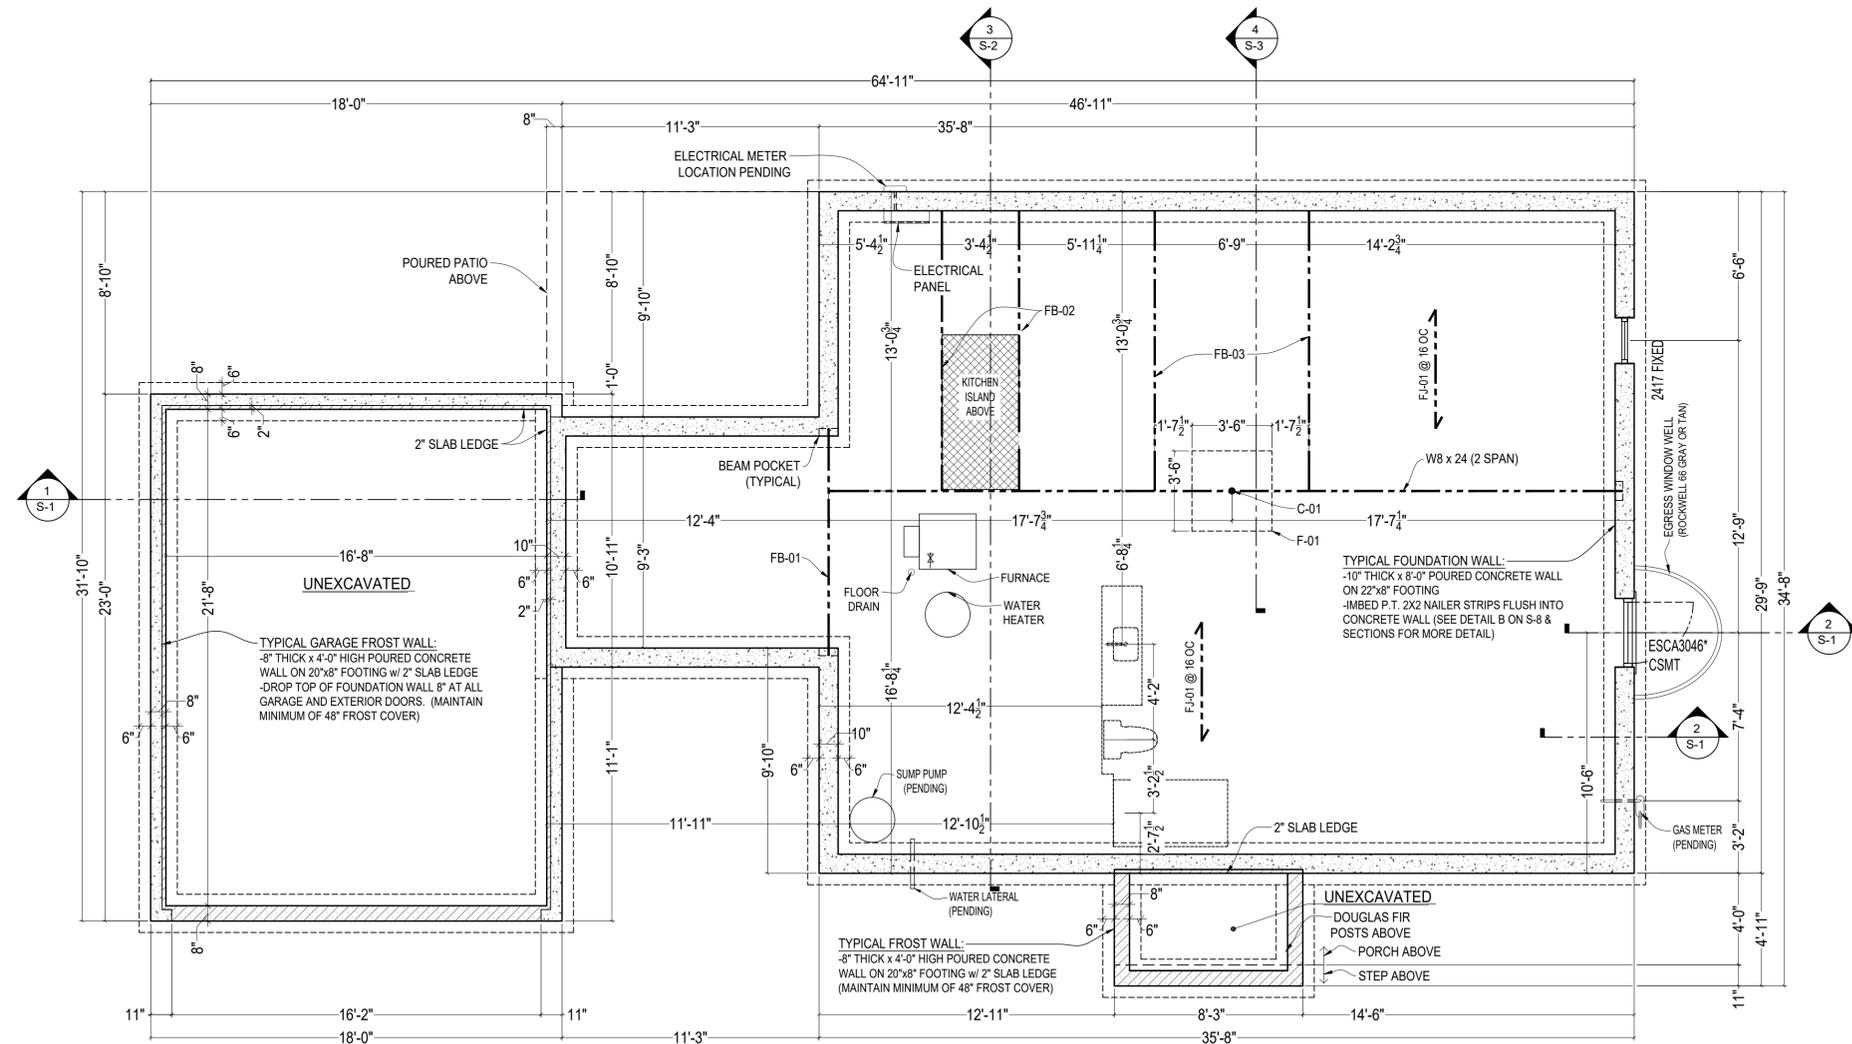

WALL LEGEND:

- NEW WALL
- BEARING WALL
- FROST WALL WALL
- FOUNDATION WALL-EXISTING TO REMAIN
- FULL EXPOSURE FROST WALL
- (1) LAYER OF CONCRETE BLOCK TO EXISTING FOUNDATION WALL



FOUNDATION PLAN

NOTE: ALL WINDOW, MECHANICAL AND STRUCTURAL INFORMATION SCHEMATIC IN NATURE.

Scale: 22x34 1/4" = 1'-0"
 11x17 1/8" = 1'-0"

Design/Build



17035 W. GREENFIELD AVENUE
 NEW BERLIN, WI 53151
 P: 414-248-5636
 E: STEVE@REDLEAFWI.COM

Sheet Title

FOUNDATION PLAN

PERMIT PLANS

Revisions

No.	Date	Description
08-08-2025	CONCEPT 1	
10-17-2025	CONCEPT 2	
12-09-2025	FOR STRUCTURAL ANALYSIS	
01-15-2026	PERMIT PLANS	

VANDE BERG RESIDENCE
 RE-BUILD

3902 N 102ND ST
 WAUWATOSA, WI 53222

Sheet No.

A-0

VENTILATION & LIGHT CODE CALCULATIONS:

BEDROOM #3:	
AREA:	137.85 S.F.
VENTILATION REQUIRED (3.5%):	4.82 S.F.
GLASS/LIGHT REQUIRED (8%):	11.03 S.F.
WINDOW GLASS PROPOSED:	11.97 S.F.

EGRESS WINDOW REQUIRED FOR ALL BEDROOMS IN LOWER LEVEL & 2ND FLOOR

-OPERABLE WINDOW CLEAR OPENING OF 20"x24"MINIMUM (WINDOW SIZE LARGER)
 -MAX HT. A.F.F. TO BE 60" TO CLEAR OPENING
 -IF 46" A.F.F. OR LESS, PERMANENT PLATFORM NOT REQUIRED
 -IF ABOVE 46" A.F.F., PLATFORM OF 20"(w)x9"(d) TO BE LOCATED DIRECTLY BELOW CLEAR OPENING.
 *VENTILATION AND LIGHT REQUIREMENTS OF 3.5%/8% ALLOW REQUIRED TO MEET CODE FOR ALL BEDROOMS.

BUILDING INFORMATION:

BASEMENT		1,191 SQ FT
-FINISHED	571 SQ FT	
-UNFINISHED	620 SQ FT	
FIRST FLOOR*		1,191 SQ FT
-FRONT PORCH**	41 SQ FT	
-PATIO	110 SQ FT	
GARAGE		405 SQ FT

NOTES:
 * INCLUDES STAIRS TO BASEMENT
 ** INCLUDES STAIR

Design/Build


REDLEAF — HOMES —

17035 W. GREENFIELD AVENUE
 NEW BERLIN, WI 53151
 P: 414-248-5636
 E: STEVE@REDLEAFWI.COM

Sheet Title

BASEMENT FLOOR PLAN

PERMIT PLANS

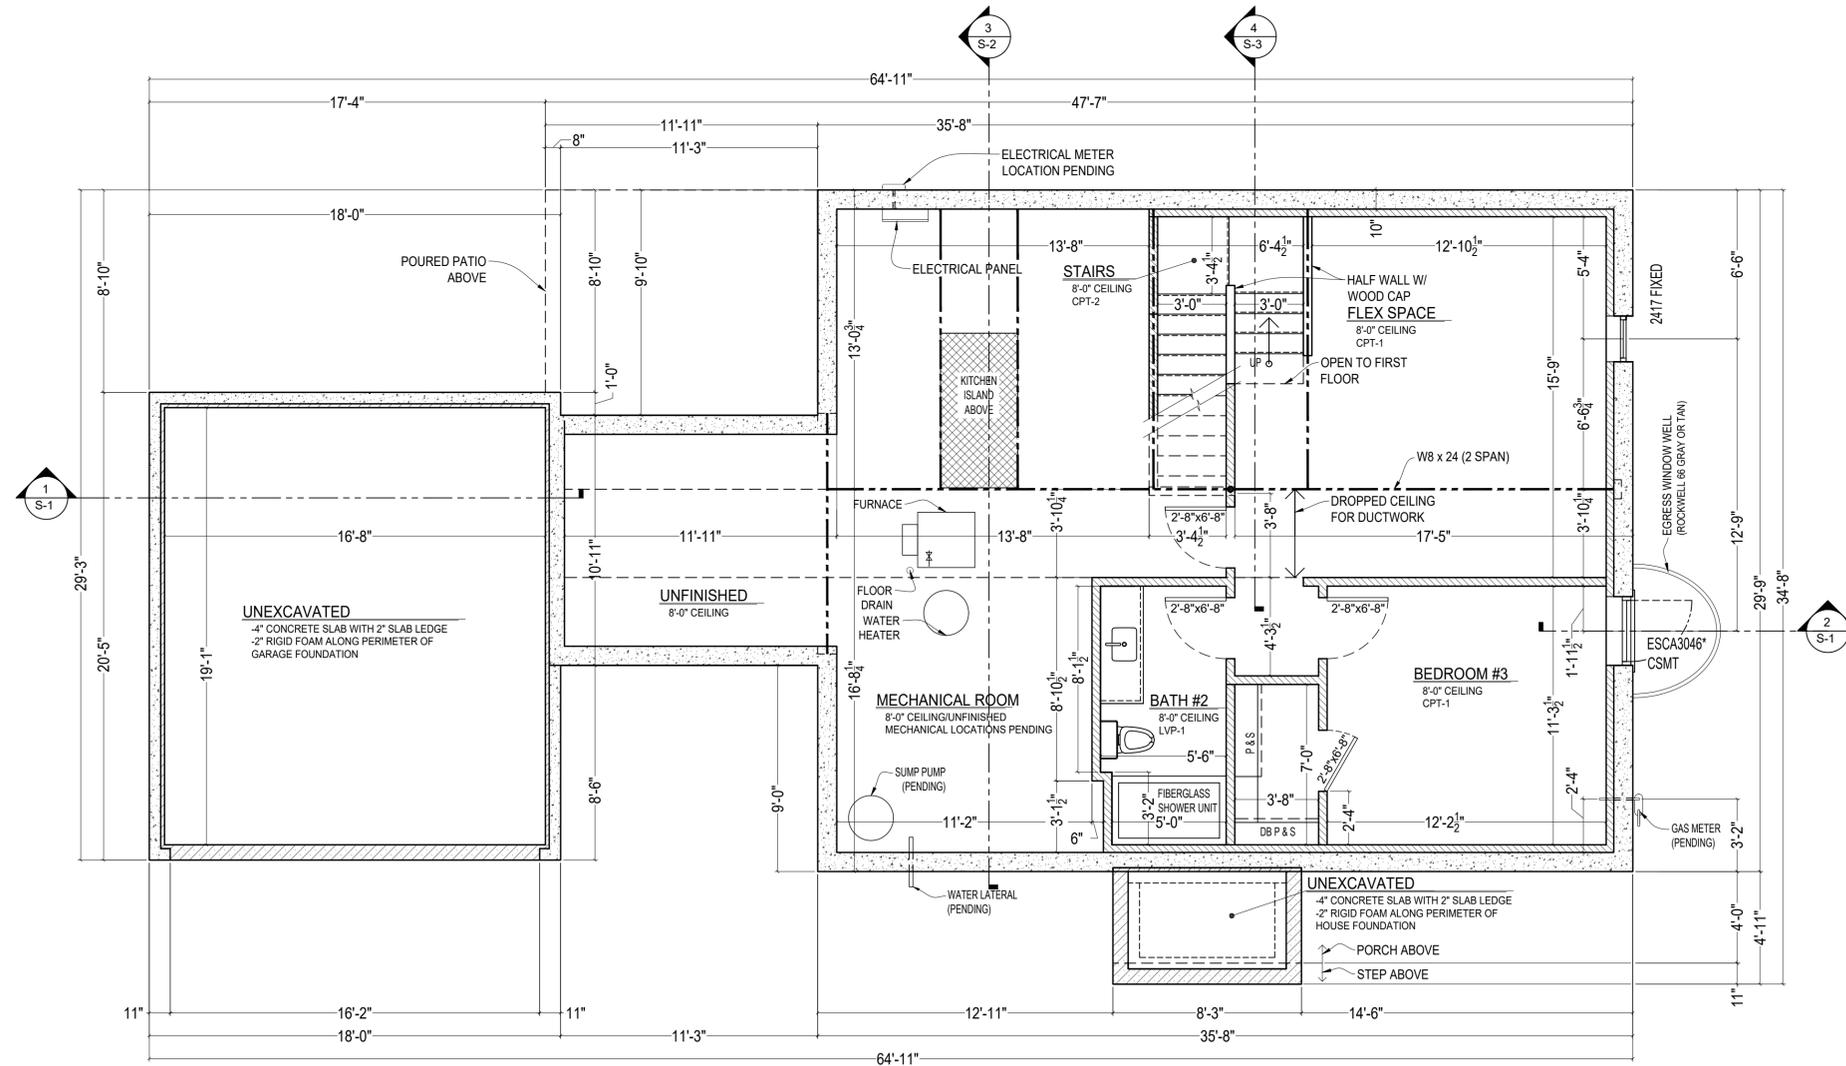

WALL LEGEND:

- NEW WALL
- BEARING WALL
- FROST WALL WALL
- FOUNDATION WALL-EXISTING TO REMAIN
- FULL EXPOSURE FROST WALL
- (1) LAYER OF CONCRETE BLOCK TO EXISTING FOUNDATION WALL

Revisions

No.	Date	Description
	08-08-2025	CONCEPT 1
	10-17-2025	CONCEPT 2
	12-09-2025	FOR STRUCTURAL ANALYSIS
	01-15-2026	PERMIT PLANS

VANDE BERG RESIDENCE
 RE-BUILD

3902 N 102ND ST
 WAUWATOSA, WI 53222

BASEMENT FLOOR PLAN

NOTE: ALL WINDOW, MECHANICAL AND STRUCTURAL INFORMATION SCHEMATIC IN NATURE.

Scale: 22x34 1/4" = 1'-0"
 11x17 1/8" = 1'-0"

Sheet No.

A-1

VENTILATION & LIGHT CODE CALCULATIONS:

PRIMARY BEDROOM:	
AREA:	174.9 S.F.
VENTILATION REQUIRED (3.5%):	6.1 S.F.
GLASS/LIGHT REQUIRED (8%):	14.0 S.F.
WINDOW GLASS PROPOSED:	38.3 S.F.
BEDROOM #2:	
AREA:	129.7 S.F.
VENTILATION REQ'D (3.5%):	4.5 S.F.
GLASS/LIGHT REQ'D (8%):	10.3 S.F.
WINDOW GLASS PROPOSED:	22.4 S.F.

BUILDING INFORMATION:

BASEMENT		1,191 SQ FT
-FINISHED	571 SQ FT	
-UNFINISHED	620 SQ FT	
FIRST FLOOR*		1,191 SQ FT
-FRONT PORCH**	41 SQ FT	
-PATIO	110 SQ FT	
GARAGE		405 SQ FT

NOTES:
 * INCLUDES STAIRS TO BASEMENT
 ** INCLUDES STAIR




17035 W. GREENFIELD AVENUE
 NEW BERLIN, WI 53151
 P: 414-248-5636
 E: STEVE@REDLEAFWI.COM

Sheet Title

FIRST FLOOR PLAN AND FRONT ELEVATION

PERMIT PLANS

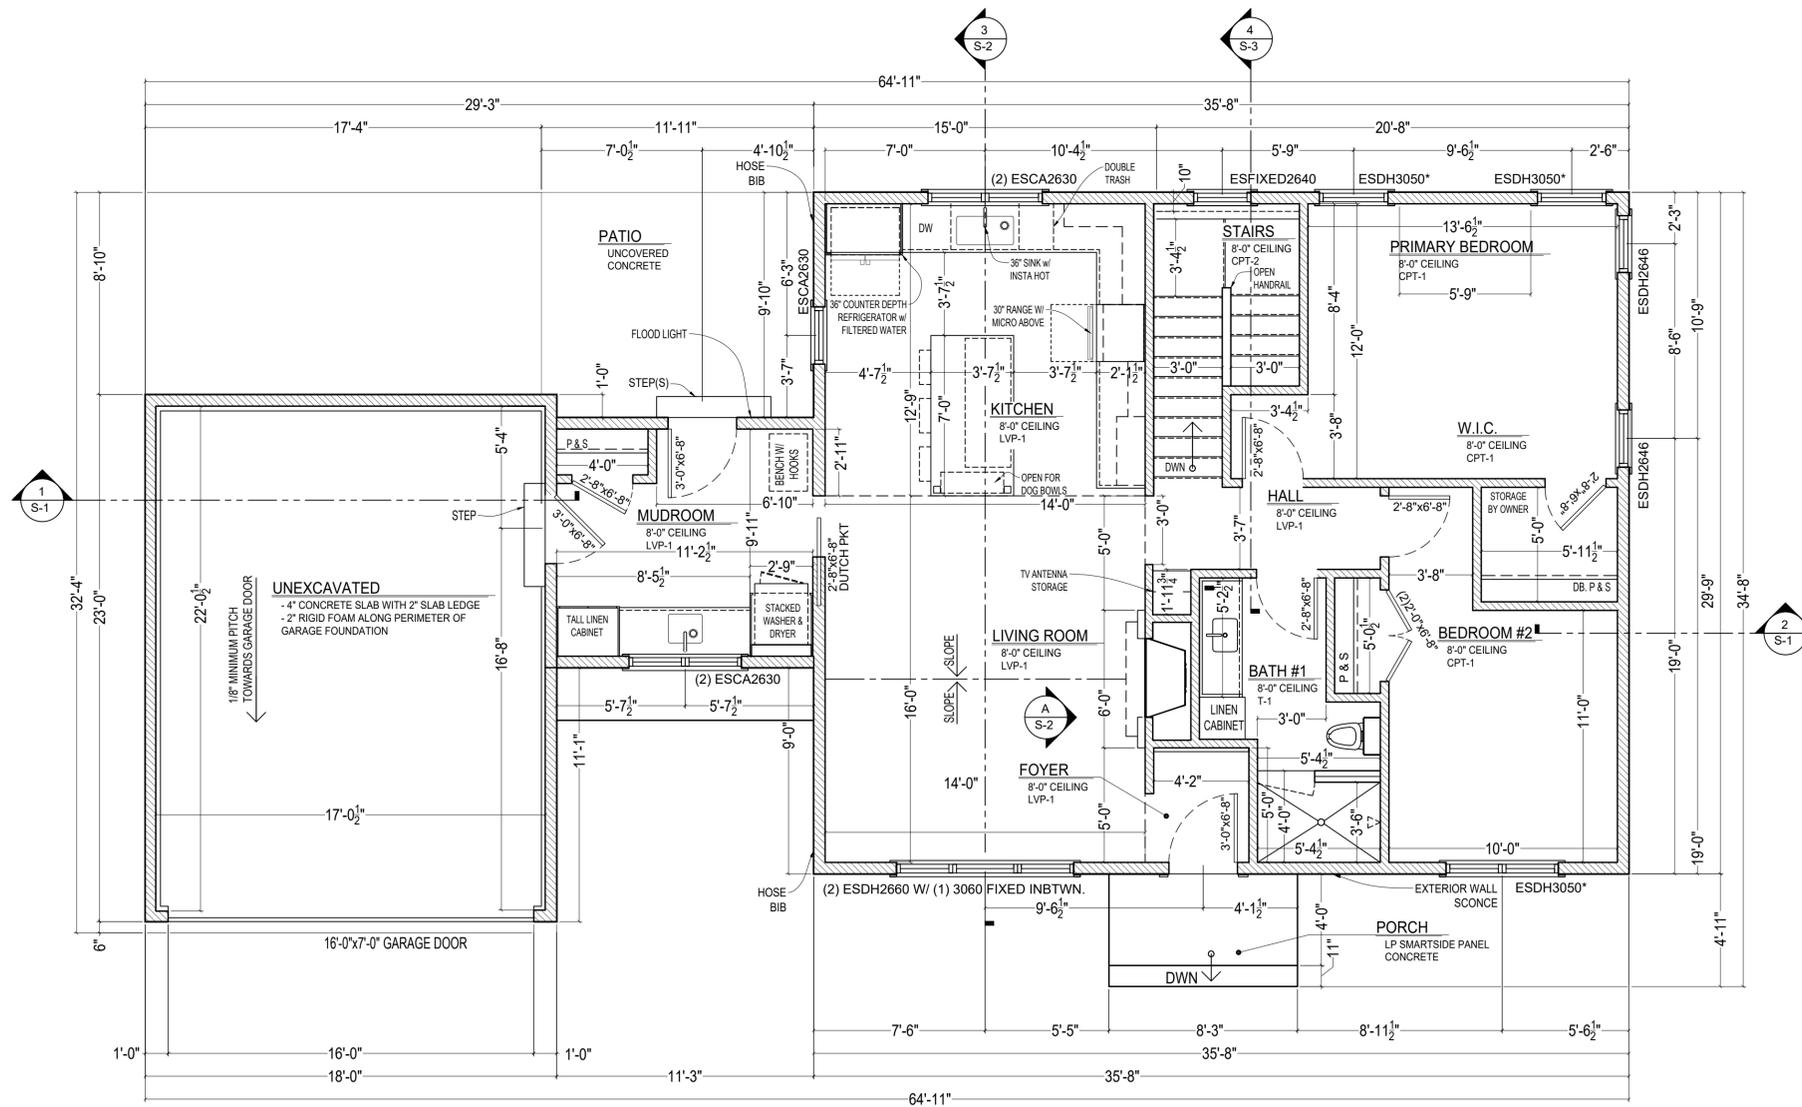

WALL LEGEND:

	NEW WALL
	BEARING WALL
	FROST WALL WALL
	FOUNDATION WALL-EXISTING TO REMAIN
	FULL EXPOSURE FROST WALL
	(1) LAYER OF CONCRETE BLOCK TO EXISTING FOUNDATION WALL



FIRST FLOOR PLAN

NOTE: ALL WINDOW, MECHANICAL AND STRUCTURAL INFORMATION SCHEMATIC IN NATURE.

Scale: 22x34 1/4" = 1'-0"
 11x17 1/8" = 1'-0"

Revisions


No.	Date	Description
	08-08-2025	CONCEPT 1
	10-17-2025	CONCEPT 2
	12-09-2025	FOR STRUCTURAL ANALYSIS
	01-15-2026	PERMIT PLANS

VANDE BERG RESIDENCE
 RE-BUILD

3902 N 102ND ST
 WAUWATOSA, WI 53222


Sheet No.

A-2

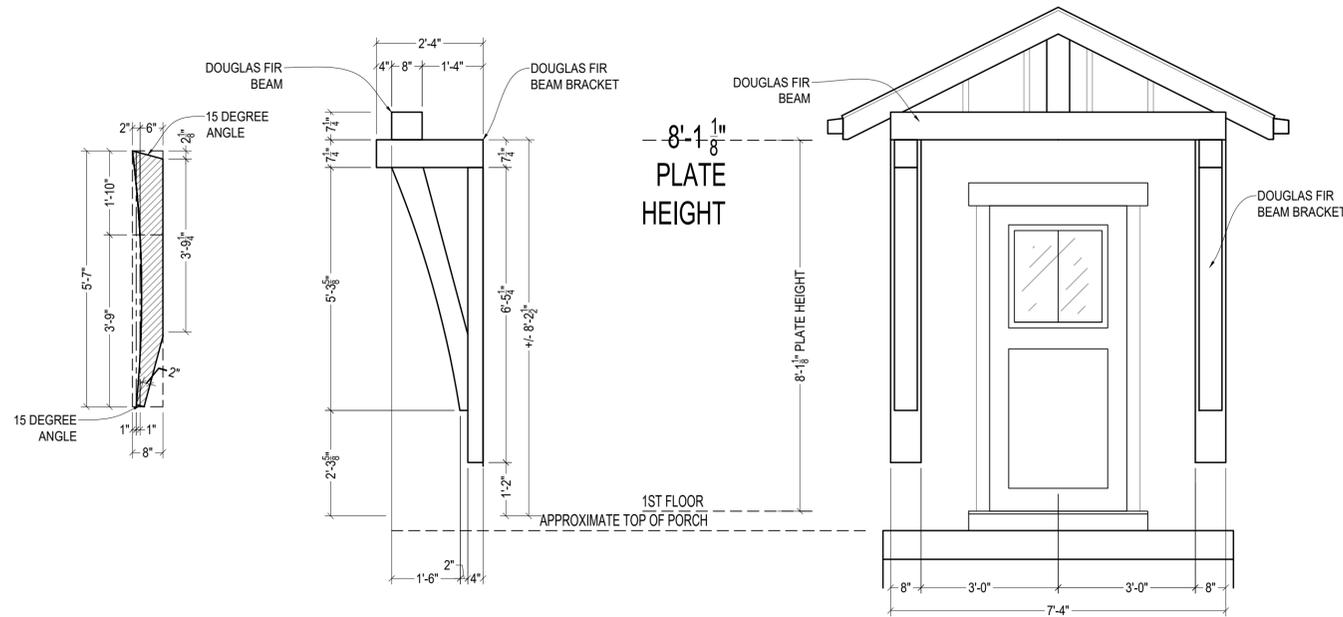


A DOUGLAS FIR BEAM & BRACKET DETAILS

Scale: 22x34 1/2" = 1'-0"
11x17 1/4" = 1'-0"

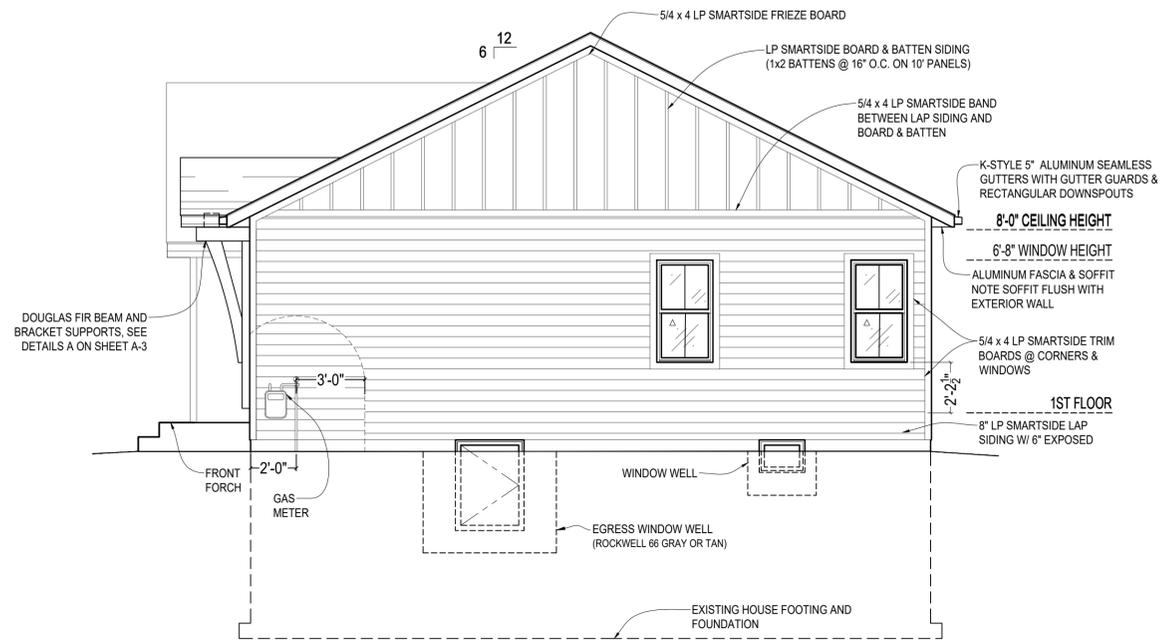

SOUTH ELEVATION

Scale: 22x34 1/4" = 1'-0"
11x17 1/8" = 1'-0"

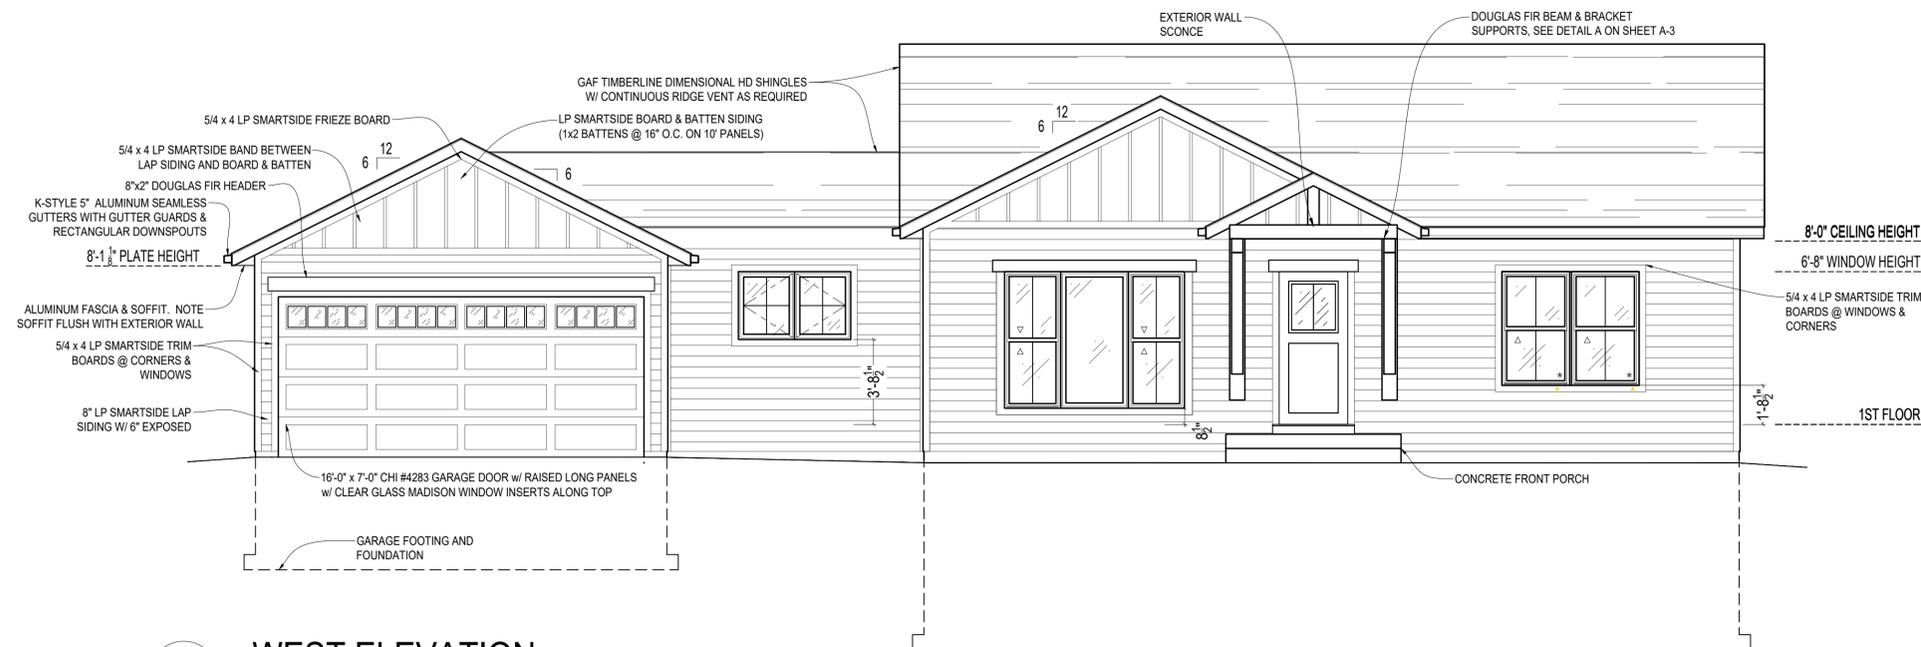

WEST ELEVATION

Scale: 22x34 1/4" = 1'-0"
11x17 1/8" = 1'-0"

No.	Date	Description
	08-08-2025	CONCEPT 1
	10-17-2025	CONCEPT 2
	12-09-2025	FOR STRUCTURAL ANALYSIS
	01-15-2026	PERMIT PLANS



17035 W. GREENFIELD AVENUE
NEW BERLIN, WI 53151
P: 414-248-5636
E: STEVE@REDLEAFWI.COM

REAR & GARAGE ELEVATIONS


PERMIT PLANS

No.	Date	Description
	08-08-2025	CONCEPT 1
	10-17-2025	CONCEPT 2
	12-09-2025	FOR STRUCTURAL ANALYSIS
	01-15-2026	PERMIT PLANS

VANDE BERG RESIDENCE
RE-BUILD


3902 N 102ND ST
WAUWATOSA, WI 53222

A-4

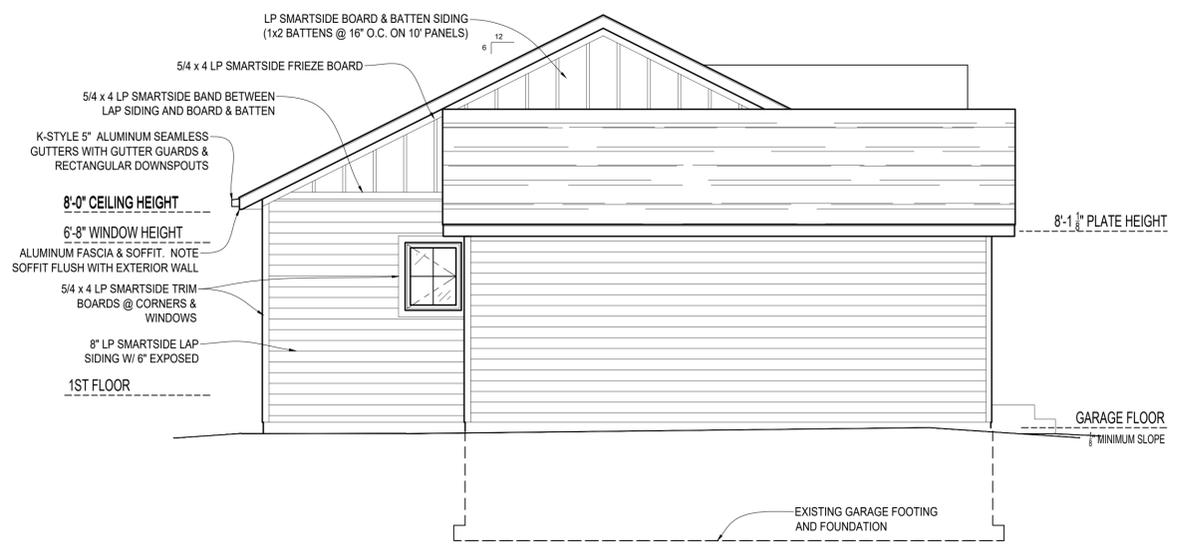


NORTH ELEVATION

Scale: 22x34 1/4" = 1'-0"
11x17 1/8" = 1'-0"

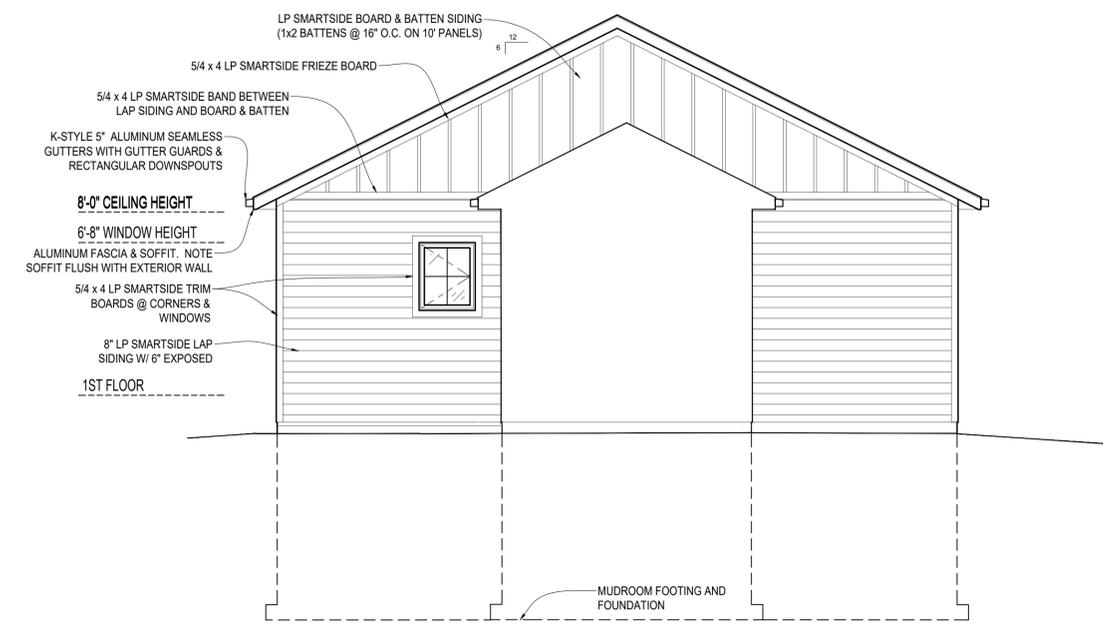


NORTH ELEVATION W/O GARAGE

Scale: 22x34 1/4" = 1'-0"
11x17 1/8" = 1'-0"

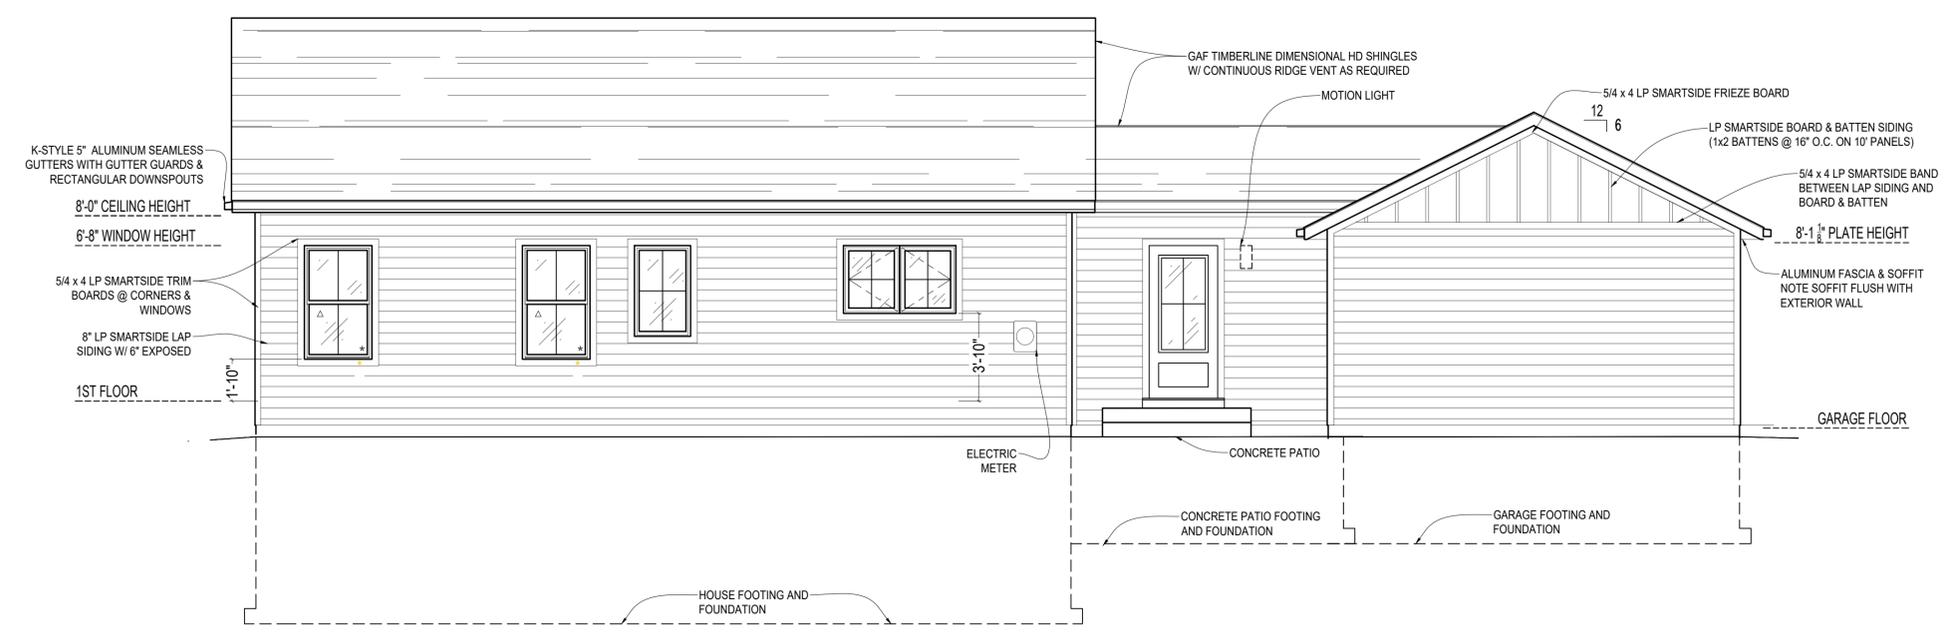

EAST ELEVATION

Scale: 22x34 1/4" = 1'-0"
11x17 1/8" = 1'-0"

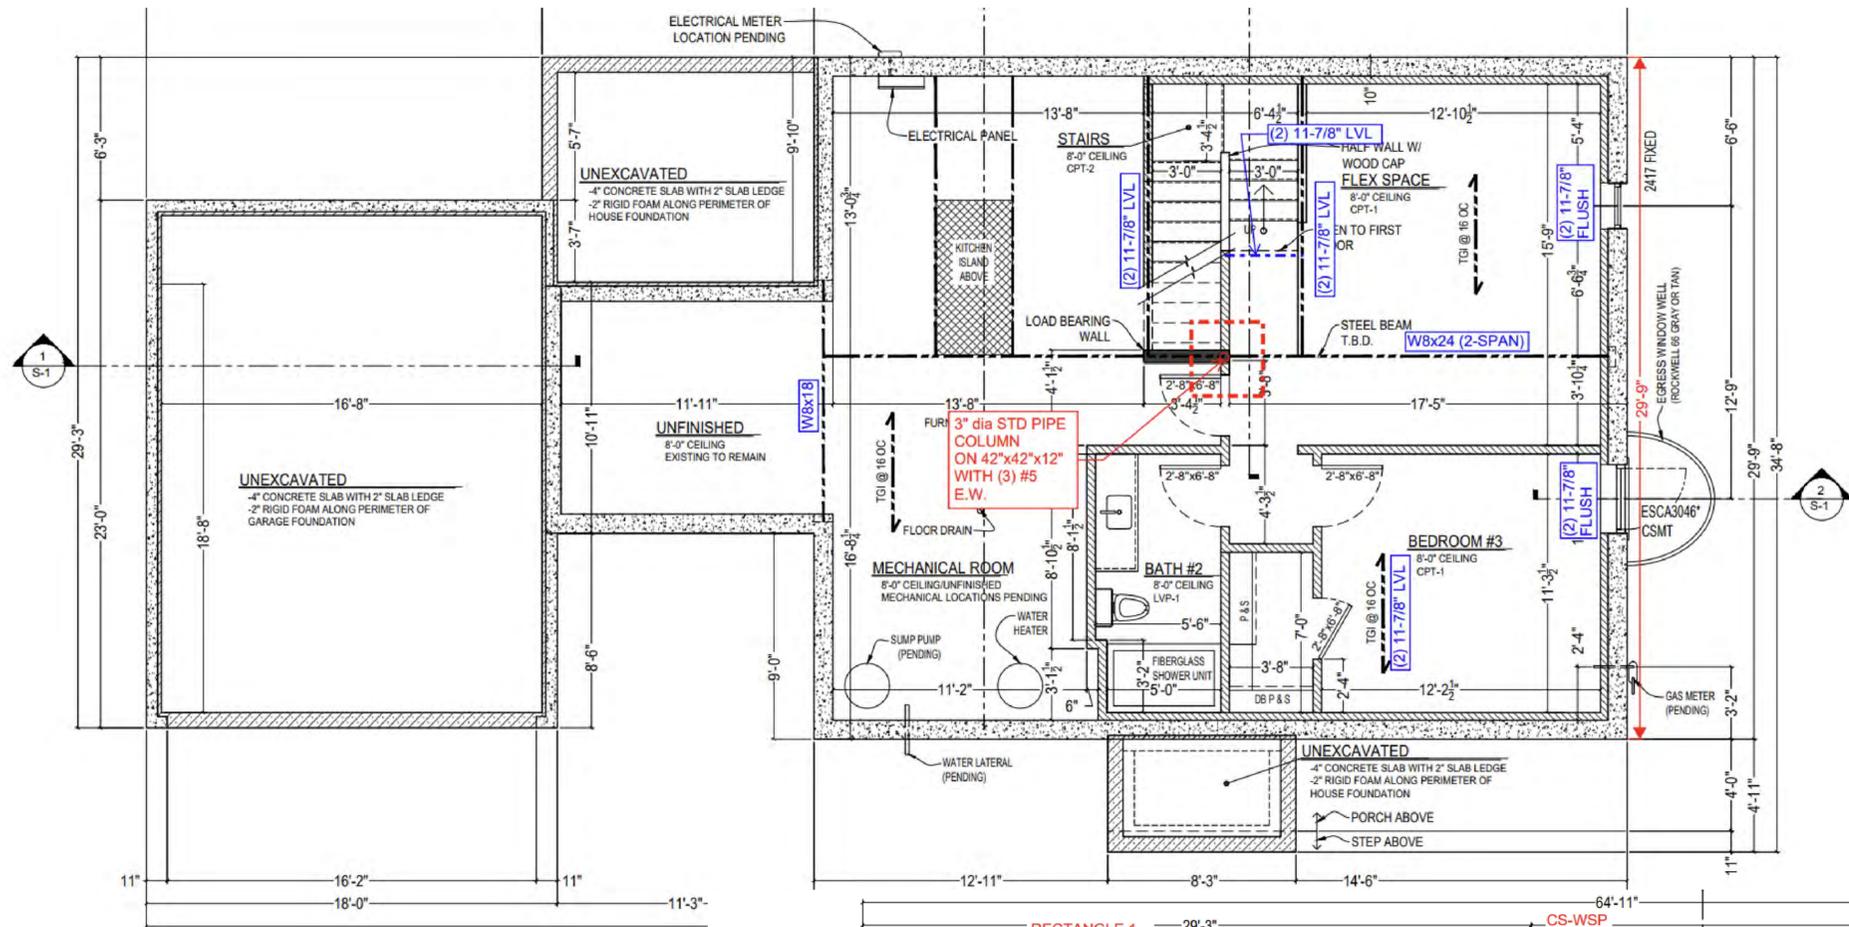

- STRUCTURAL NOTES:**
- ALL WOOD IN CONTACT WITH CONCRETE MUST BE PRESSURE TREATED.
 - 1/2" OSB SHALL BE NAILED TO TRUSSES AT A MAXIMUM OF 8" O.C.. STEEL H-CLIPS SHALL BE USED BETWEEN TRUSSES.
 - ALL WOOD FOR EXTERIOR WALLS, INTERIOR BEARING WALLS SHALL BE SPF #2 GRADE OR BETTER UNLESS OTHERWISE NOTED.
 - FLOOR JOISTS SHALL BE ENGINEERED JOIST.
 - ALL WOOD REQUIRED TO COMPLETE THE ROOF SHALL BE PER ROOF TRUSS MANUFACTURER SPECIFICATIONS.
 - ALL CONCRETE BLOCK SHALL BE STATE OF WISCONSIN APPROVED. BRICK SHALL BE SECURELY ATTACHED TO WOOD FRAMING WITH 22 GAGE CORRUGATED GALVANIZED SHEET METAL TIES-7/8" WIDE WITH AT LEAST ON ANCHOR IN EVERY 2 SQ. FT. OF WALL. MORTAR SHALL BE TYPE "M".
 - TRUSS MANUFACTURER TO VERIFY FIREPLACE VENTING SPACE FOR ALL FIREPLACES.

Sheet Title
**STRUCTURAL PLANS,
 STRUCTURAL KEY AND
 STRUCTURAL NOTES**
 PERMIT PLANS

BASEMENT STRUCTURAL PLAN
 Scale: 22x34 1/4" = 1'-0"
 11x17 1/8" = 1'-0"

STRUCTURAL KEY:

FOOTINGS:
 F-01: 42"x 42" x 12" W/ (3) #5 E. W.

FLOOR FRAMING:
 FJ-01: (2) 11-7/8" LVL


BEAMS:
 FB-01: W8 x 18
 FB-02: (2) 11-7/8" LVL
 FB-03: (2) 11-7/8" LVL

HEADERS-WINDOW & DOOR:
 H-01: SEE SHEET S-0

STEEL COLUMNS:
 C-01: 3" DIAMETER STANDARD PIPE COLUMN

ROOF FRAMING:
 PRE-ENGINEERED TRUSSED DESIGNED BY TRUSS COMPANY

WALL BRACING:
WSP: WOOD STRUCTURAL PANEL SHEATHING, MIN. 48" LONG, MIN. 7/16" OSB OR PLYWOOD SHEATHING FASTENED WITH 8d NAILS @ 6" O.C. ALONG ALL PANEL EDGES AND 12" O.C. IN THE FIELD. PROVIDE BLOCKING AT ALL PANEL JOINTS.
PF: PORTAL FRAME (NARROW WALL BRACING) PER WISCONSIN UNIFORM DWELLING CODE (UDC) FIGURE 321.25-A.
CS-WSP: CONTINUOUSLY SHEATHED SHEARWALL WITH WOOD STRUCTURAL PANEL SHEATHING ON ENTIRE LENGTH OF WALL, FULL HEIGHT DIMENSIONS AS SHOWN ON PLAN. MIN 7/16" OSB OR PLYWOOD SHEATHING FASTENED WITH 8d NAILS @ 6" O.C. ALONG ALL PANEL EDGES & 12" O.C. IN THE FIELD. PROVIDE BLOCKING AT ALL PANEL JOINTS.

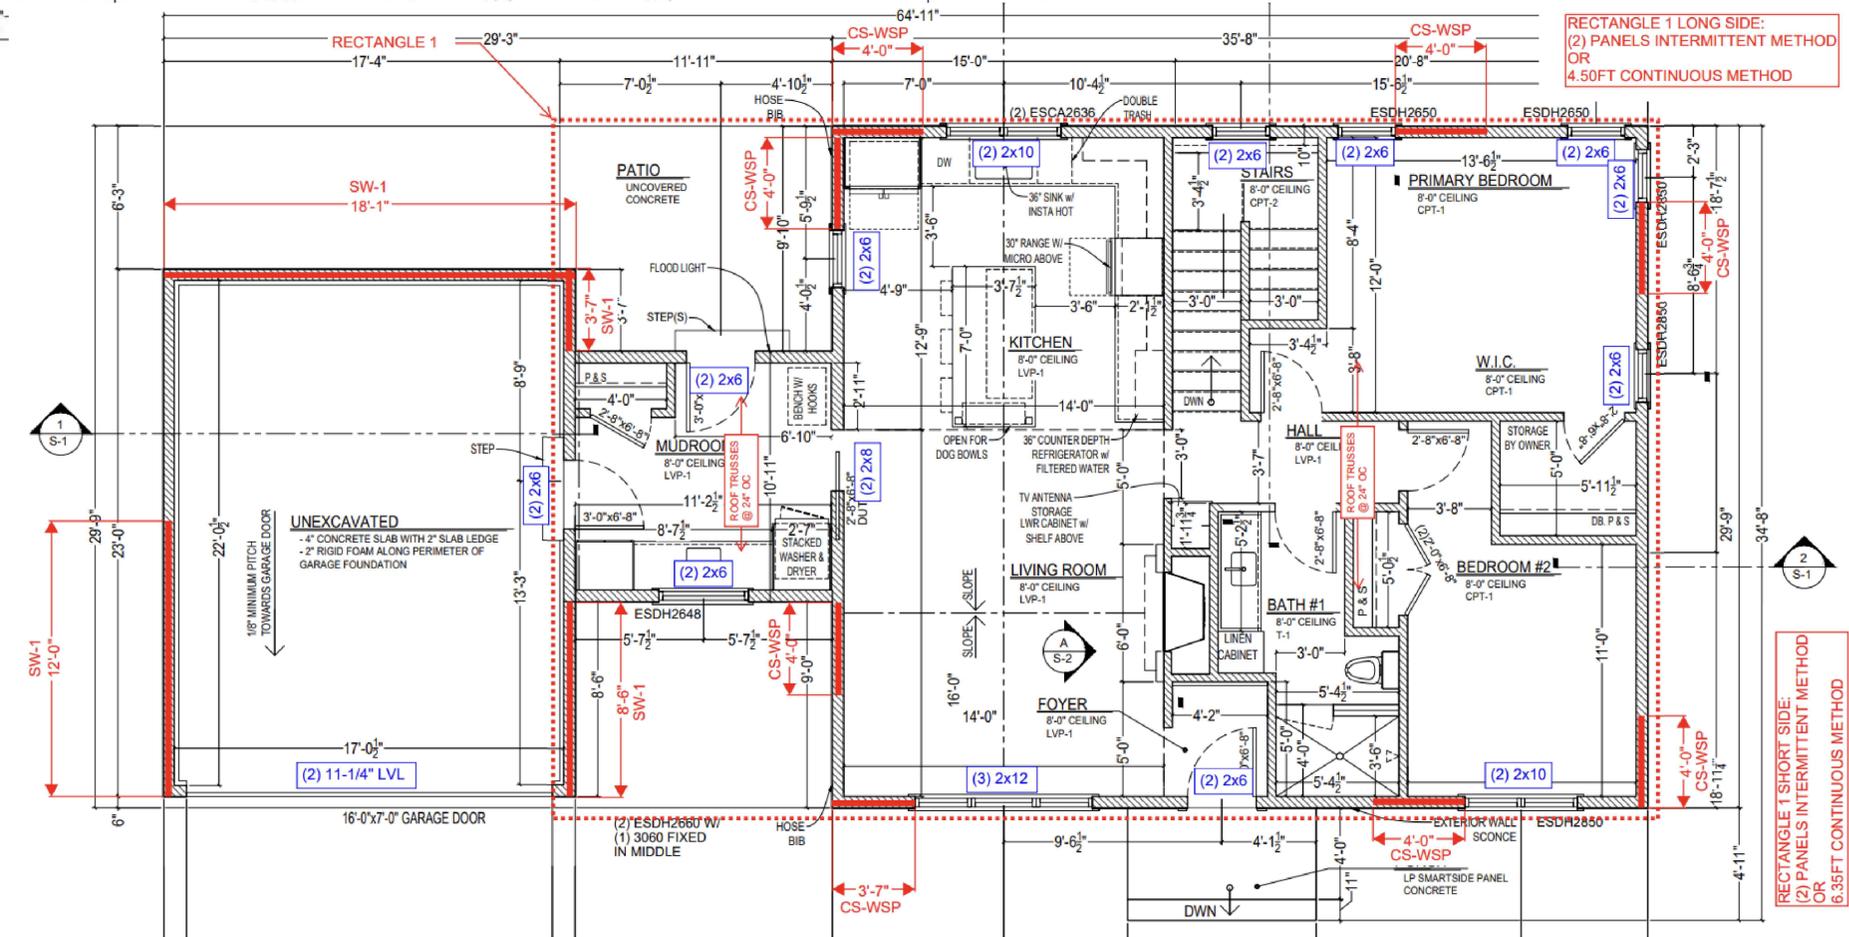


FIRST FLOOR STRUCTURAL PLAN
 Scale: 22x34 1/4" = 1'-0"
 11x17 1/8" = 1'-0"

Revisions

No.	Date	Description
	08-08-2025	CONCEPT 1
	10-17-2025	CONCEPT 2
	12-09-2025	FOR STRUCTURAL ANALYSIS
	01-15-2026	PERMIT PLANS


VANDE BERG RESIDENCE
 RE-BUILD
 3902 N 102ND ST
 WAUWATOSA, WI 53222

Sheet No.
S-0

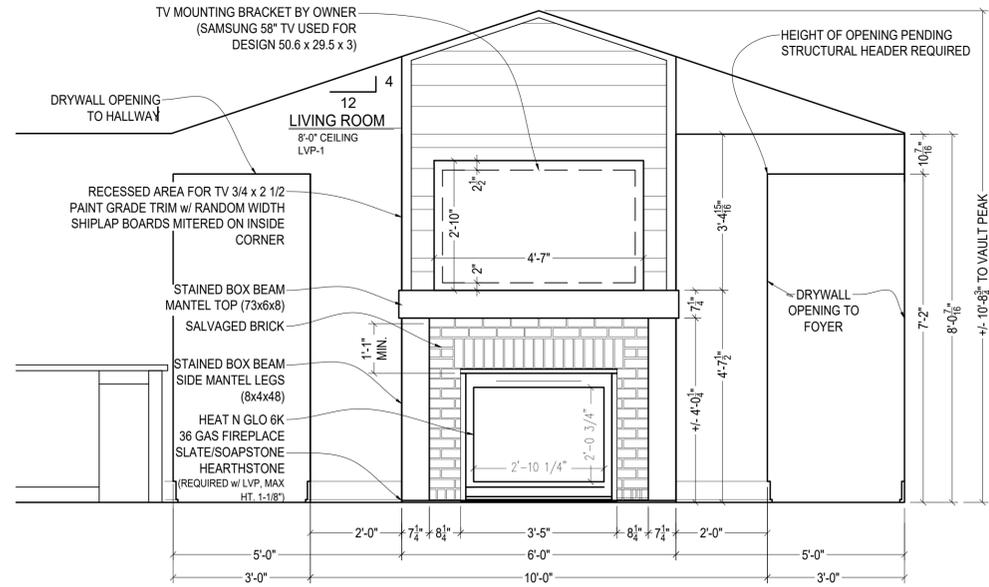

A FIREPLACE INTERIOR ELEVATION

Scale: 22x34 1/2" = 1'-0"
11x17 1/4" = 1'-0"

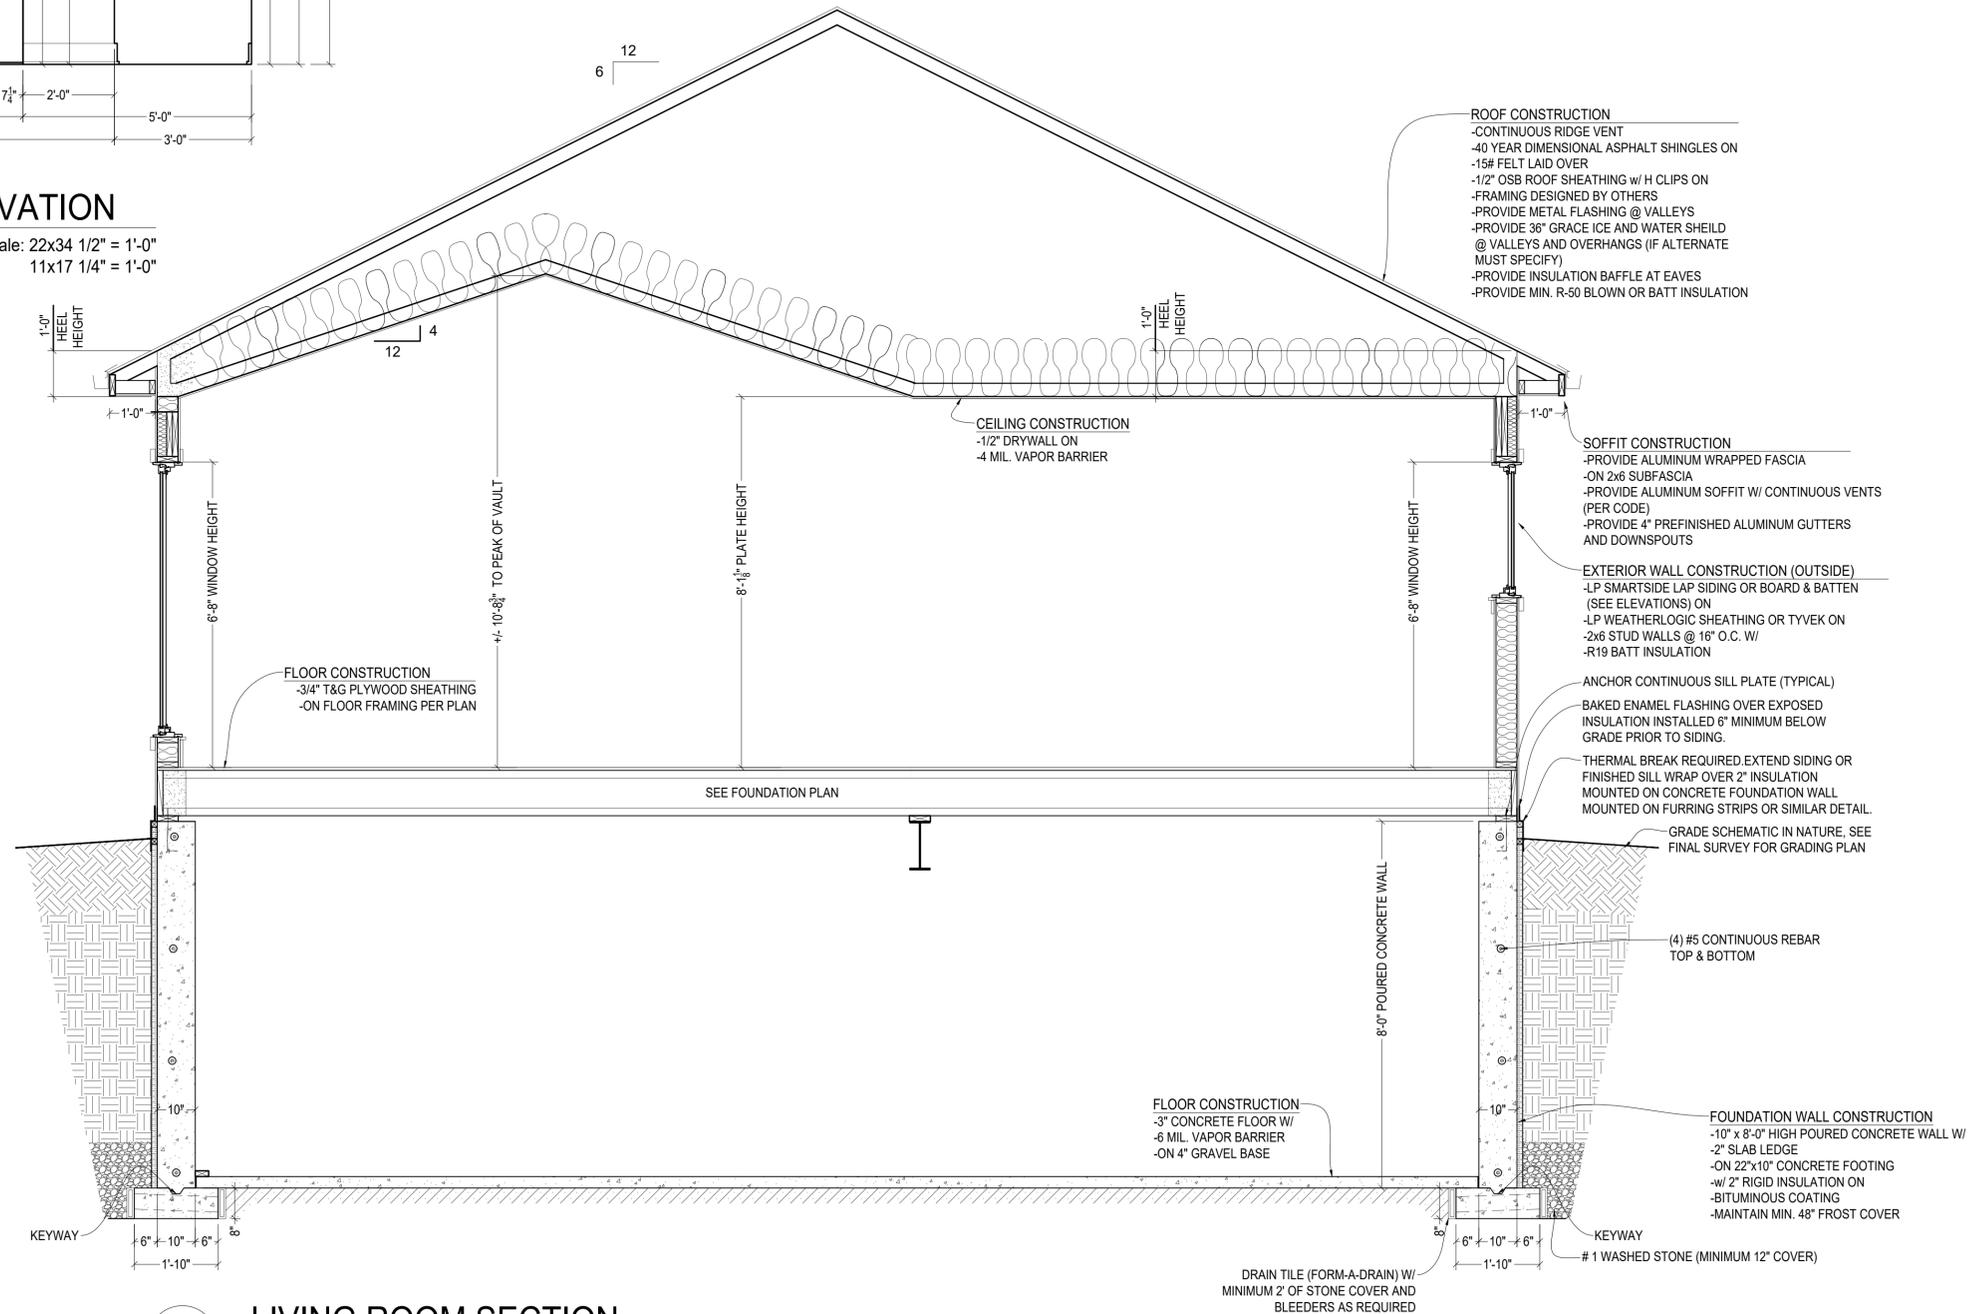

3 LIVING ROOM SECTION

Scale: 22x34 1/2" = 1'-0"
11x17 1/4" = 1'-0"

Design/Build



17035 W. GREENFIELD AVENUE
NEW BERLIN, WI 53151
P: 414-248-5636
E: STEVE@REDLEAFWI.COM

Sheet Title

LIVING ROOM WALL SECTION AND FIREPLACE ELEVATION

PERMIT PLANS

Revisions


No.	Date	Description
	08-08-2025	CONCEPT 1
	10-17-2025	CONCEPT 2
	12-09-2025	FOR STRUCTURAL ANALYSIS
	01-15-2026	PERMIT PLANS

VANDE BERG RESIDENCE
RE-BUILD

3902 N 102ND ST
WAUWATOSA, WI 53222

Sheet No.

S-2

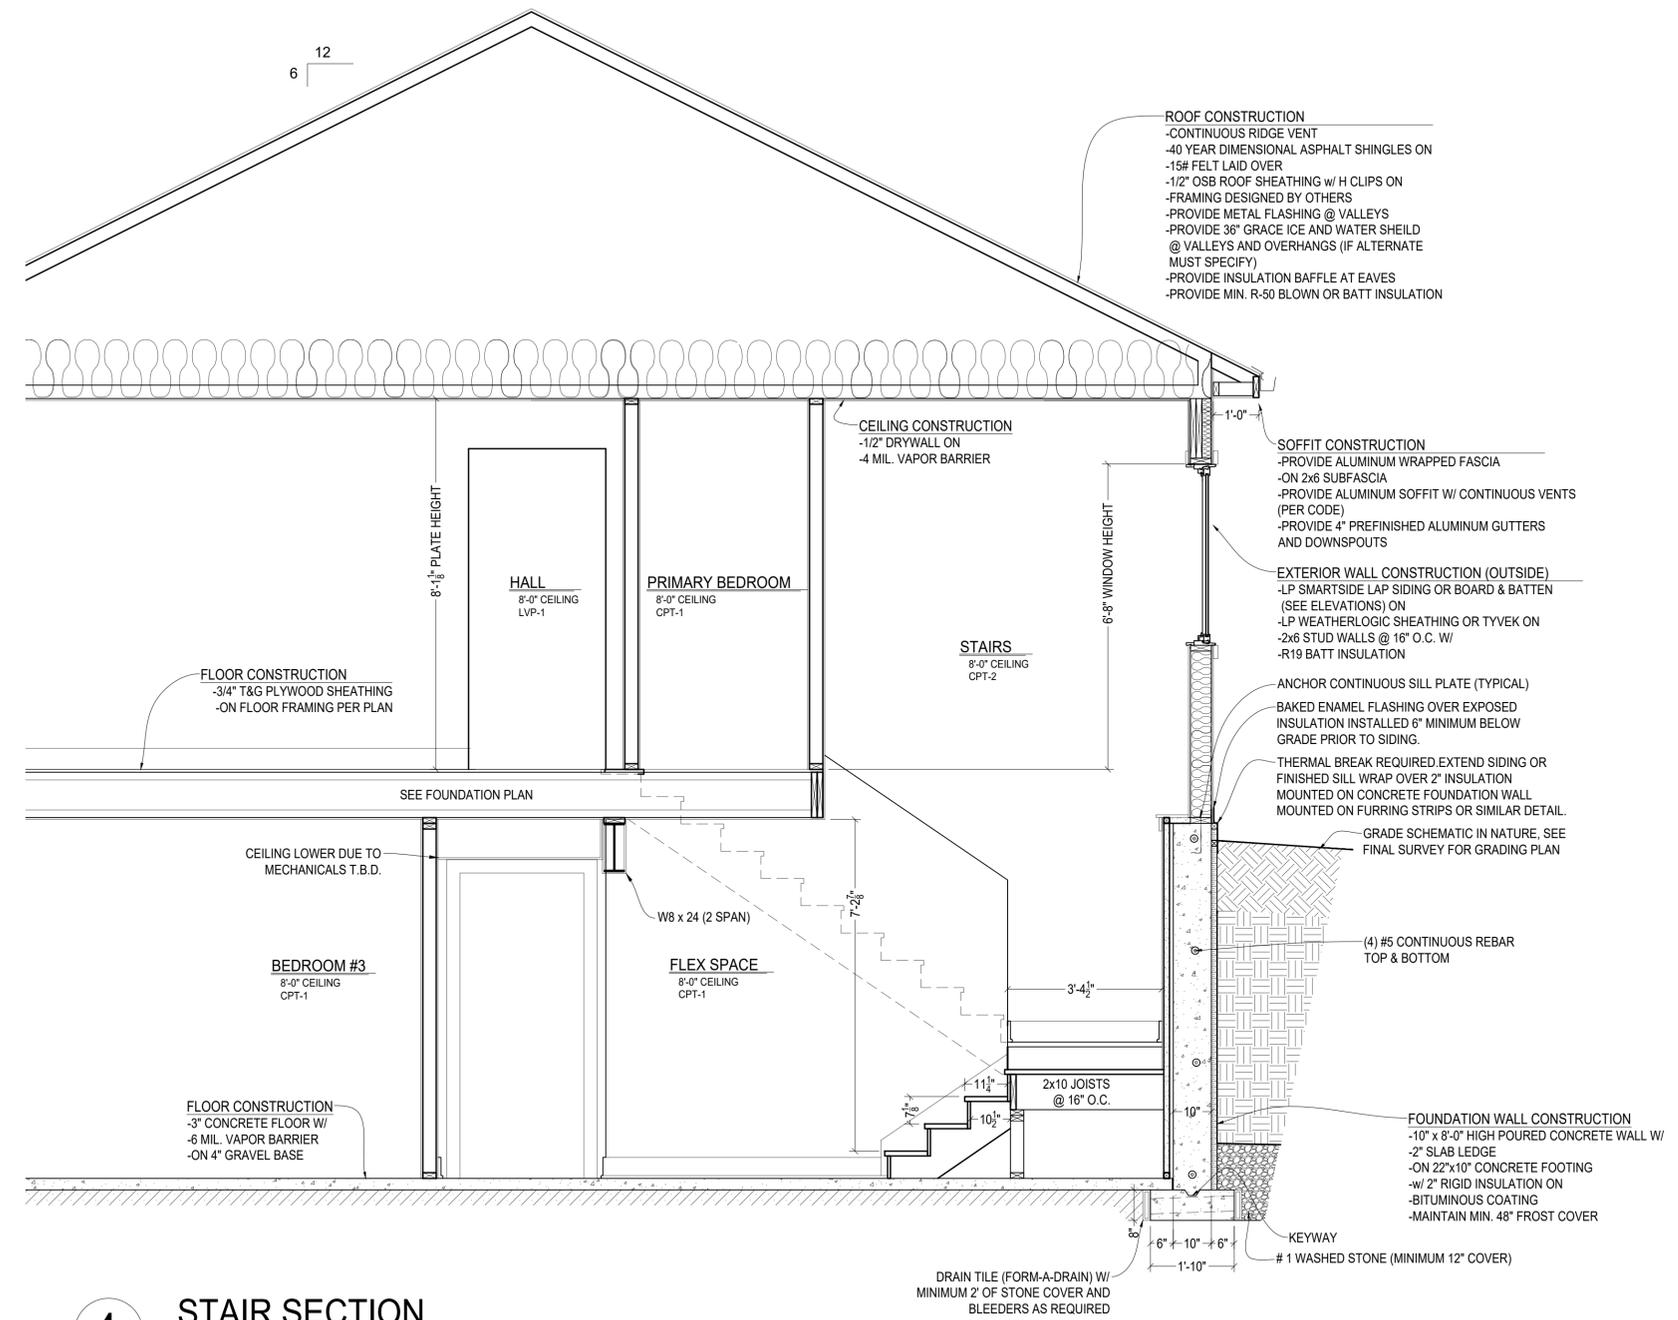

Sheet Title
STAIR SECTION 4 AND STRUCTURAL DESIGN DATA
 PERMIT PLANS

Revisions

No.	Date	Description
	08-08-2025	CONCEPT 1
	10-17-2025	CONCEPT 2
	12-09-2025	FOR STRUCTURAL ANALYSIS
	01-15-2026	PERMIT PLANS

DESIGN DATA:

LIVE LOAD ROOF: 30#/SQ. FT.
 LIVE LOAD FLOOR: 40#/SQ. FT.
 LIVE LOAD STAIRS: 40#/SQ. FT.
 WIND LOAD: 20#/SQ. FT.
 CONCRETE: 3,000 PSI
 REINFORCED STEEL YIELD: 60,000 PSI.
 CRSI SPECIFICATIONS.
 COMPACTION OF ANY FILL REQUIRED UNDER FLOOR SHALL BE TO 95% MAXIMUM DENSITY AS DETERMINED BY MODIFIED PROCOTOR TEST (ASTM 1557). THIRD PARTY TESTS SHALL BE REQUIRED TO BE FURNISHED TO DESIGNER TO INSURE THAT THE COMPACTION IS PER


4 STAIR SECTION

Scale: 22x34 1/2" = 1'-0"
 11x17 1/4" = 1'-0"


VANDE BERG RESIDENCE
 RE-BUILD
 3902 N 102ND ST
 WAUWATOSA, WI 53222

Sheet No.
S-3


No.	Date	Description
	08-08-2025	CONCEPT 1
	10-17-2025	CONCEPT 2
	12-09-2025	FOR STRUCTURAL ANALYSIS
	01-15-2026	PERMIT PLANS

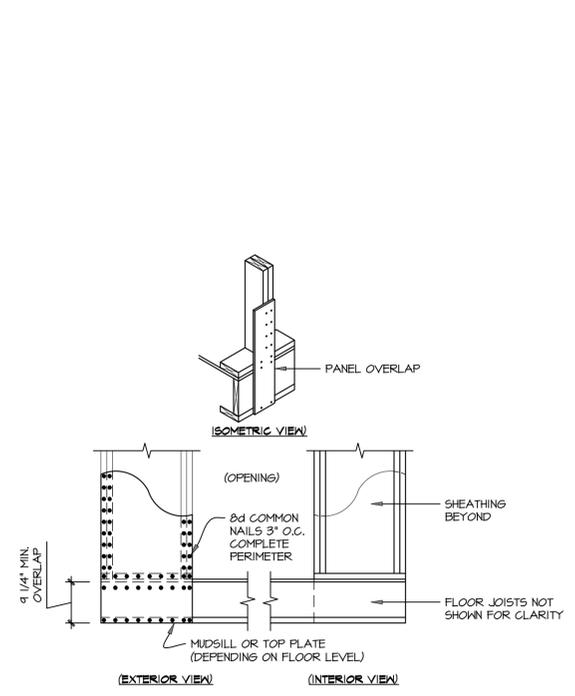


4 "PF" BOTTOM CONNECTION
 1/2" = 1'-0"

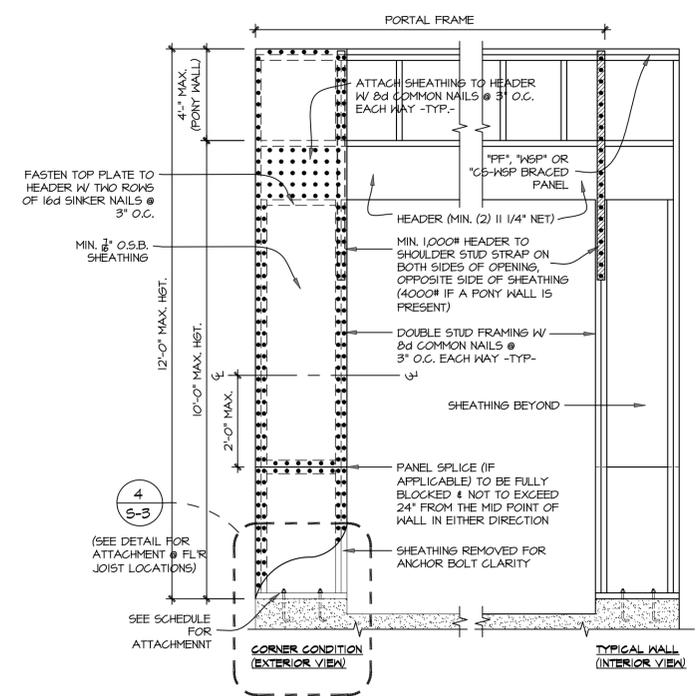


3 "PF" PORTAL FRAME DETAIL
 1/2" = 1'-0"

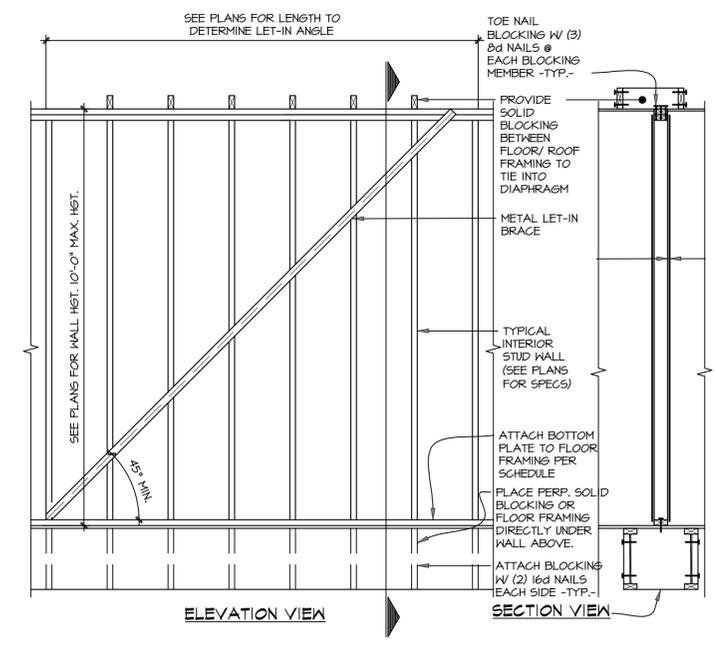


2 "LIB" INTERIOR LET-IN BRACED DETAIL
 1/2" = 1'-0"

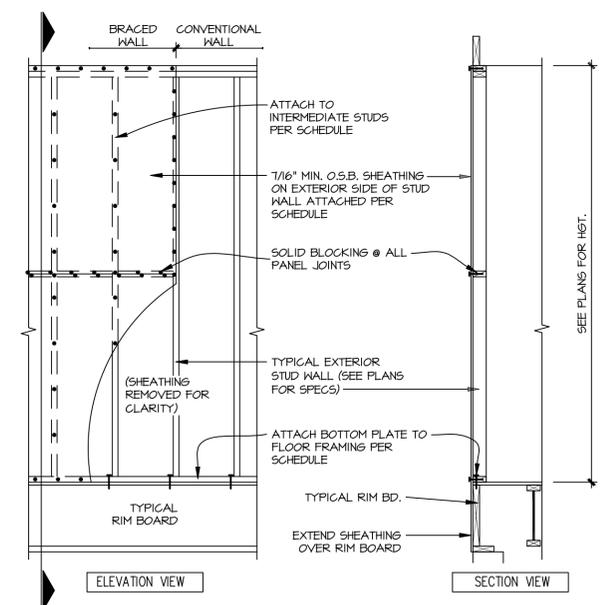

1 "WSP" & "CS-WSP" SHEATHED WOOD STRUCTURAL PANEL DETAIL
 1/2" = 1'-0"

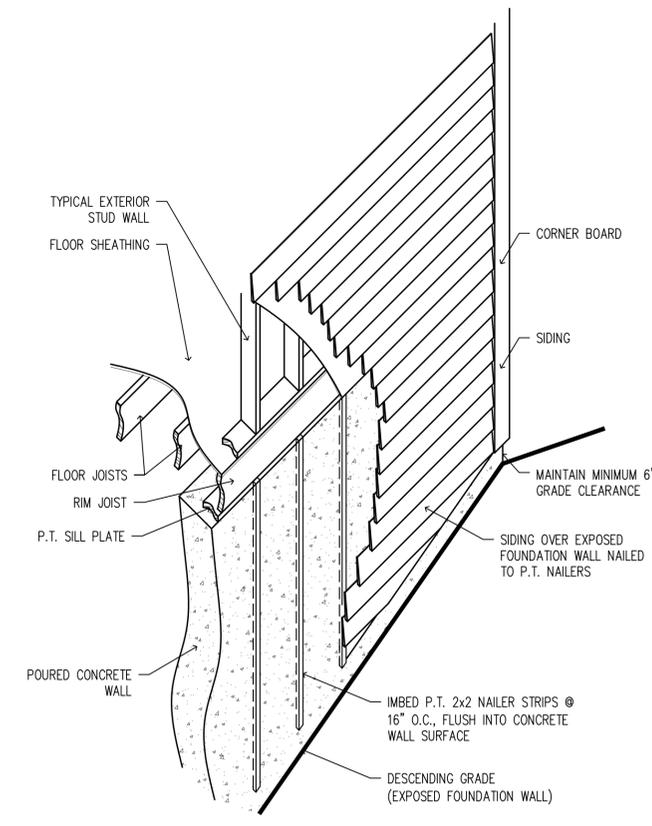

5 SIDING OVER CONCRETE WALL DETAIL
 NOT TO SCALE

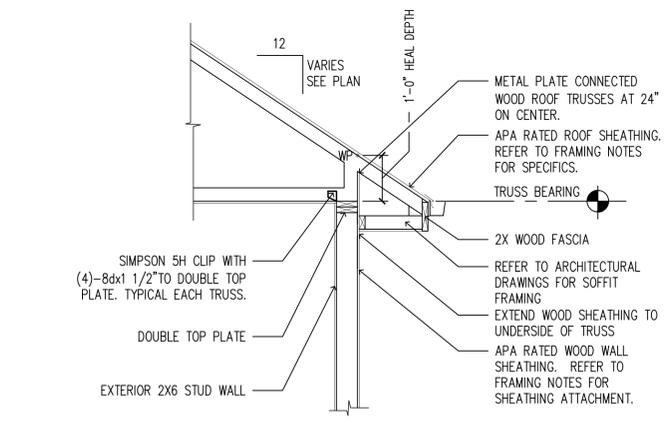

6 TYPICAL TRUSS FRAMING DETAIL
 Scale: 22x34 1/2" = 1'-0"
 11x17 1/4" = 1'-0"